


RAILWAY CORRIDOR PARK

LANDSCAPE WORKS DOCUMENT

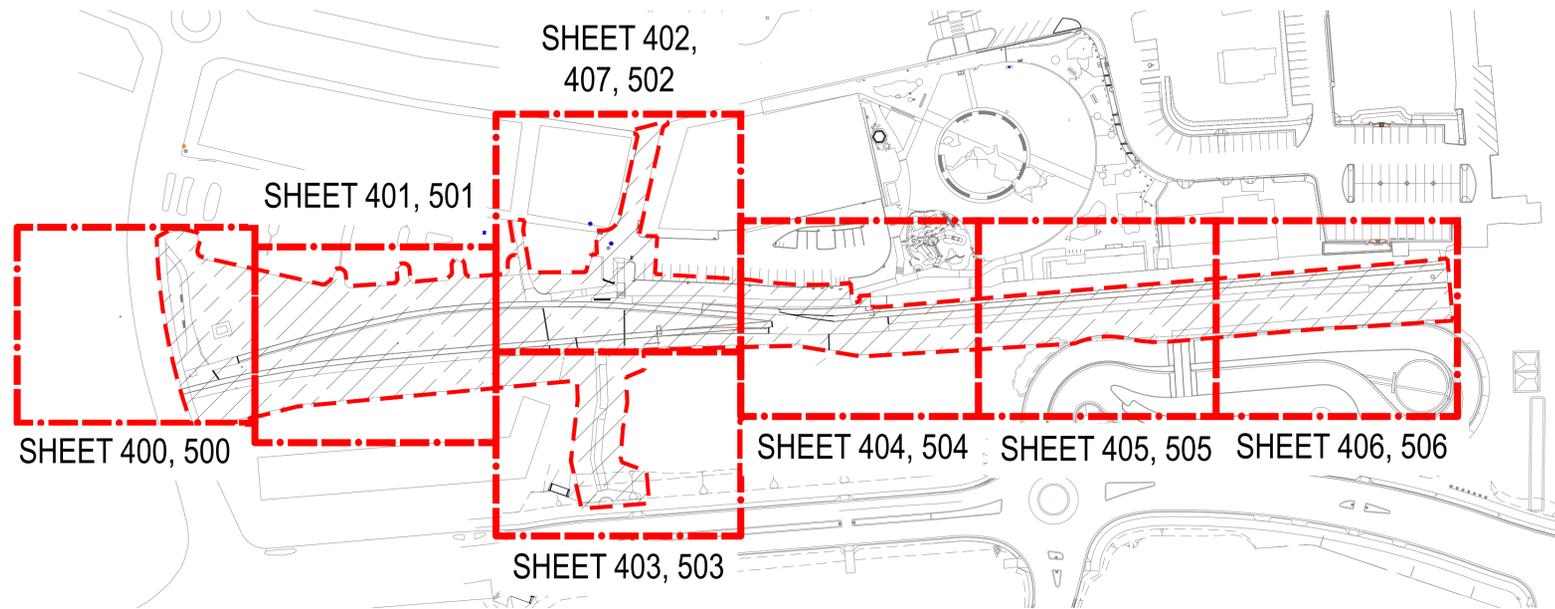

LANDSCAPE DRAWING LIST		
DRAWING No.	REV	TITLE
211-000	C	COVER SHEET AND DRAWING LIST
211-100	B	DEMOLITION PLAN
211-101	B	DEMOLITION PLAN
211-102	B	DEMOLITION PLAN
211-400	C	HARDWORKS & EARTHWORKS PLAN
211-401	C	HARDWORKS & EARTHWORKS PLAN
211-402	C	HARDWORKS & EARTHWORKS PLAN
211-403	C	HARDWORKS & EARTHWORKS PLAN
211-404	C	HARDWORKS & EARTHWORKS PLAN
211-405	C	HARDWORKS & EARTHWORKS PLAN
211-406	C	HARDWORKS & EARTHWORKS PLAN
211-407	A	BYRON LANE SIGNAGE PLAN
211-500	B	SOFTWORKS PLAN
211-501	B	SOFTWORKS PLAN
211-502	B	SOFTWORKS PLAN
211-503	B	SOFTWORKS PLAN
211-504	B	SOFTWORKS PLAN
211-505	B	SOFTWORKS PLAN
211-506	B	SOFTWORKS PLAN
211-507	B	SOFTWORKS SCHEDULE
211-600	C	CROSS SECTIONS
211-900	C	CONSTRUCTION DETAILS
211-901	C	CONSTRUCTION DETAILS
211-902	C	CONSTRUCTION DETAILS
211-903	C	CONSTRUCTION DETAILS
211-904	C	CONSTRUCTION DETAILS
211-905	C	CONSTRUCTION DETAILS
211-906	C	CONSTRUCTION DETAILS
211-907	C	CONSTRUCTION DETAILS
211-908	C	CONSTRUCTION DETAILS
211-909	C	CONSTRUCTION DETAILS
211-910	C	CONSTRUCTION DETAILS
211-911	B	CONSTRUCTION DETAILS
211-912	A	CONSTRUCTION DETAILS
SUB- CONSULTANT PLANS TO BE READ IN CONJUNCTION WITH LANDSCAPE DOCUMENT SET.		
WATER SERVICE PLAN		
LIGHTING AND ELECTRICAL PLAN		
STRUCTURAL ENGINEERING PLANS		

Revision	Description	Date	Initial
C	FOR TENDER	31.07.20	
B	FINAL DRAFT FOR REVIEW	19.06.20	
A	PRELIMINARY- FOR INFORMATION ONLY	25.05.20	



1:1000 @ A1

PLUMMER & SMITH


landscape architecture / art / design
 abn: 17 634 944 737 m 0437 599 011
 po box 204 e dan@plummerandsmith.com.au
 manlywinds NSW 2484 w plummerandsmith.com.au
 © Copyright

BYRON SHIRE COUNCIL

RAIL CORRIDOR PARK

COVERSHEET AND DRAWING LIST

Designed DP	Drawn EC
Checked DP	Approved
Date 25.05.2020	Scale 1:1000
Job No. 211	Drawing No. 000 Revision C

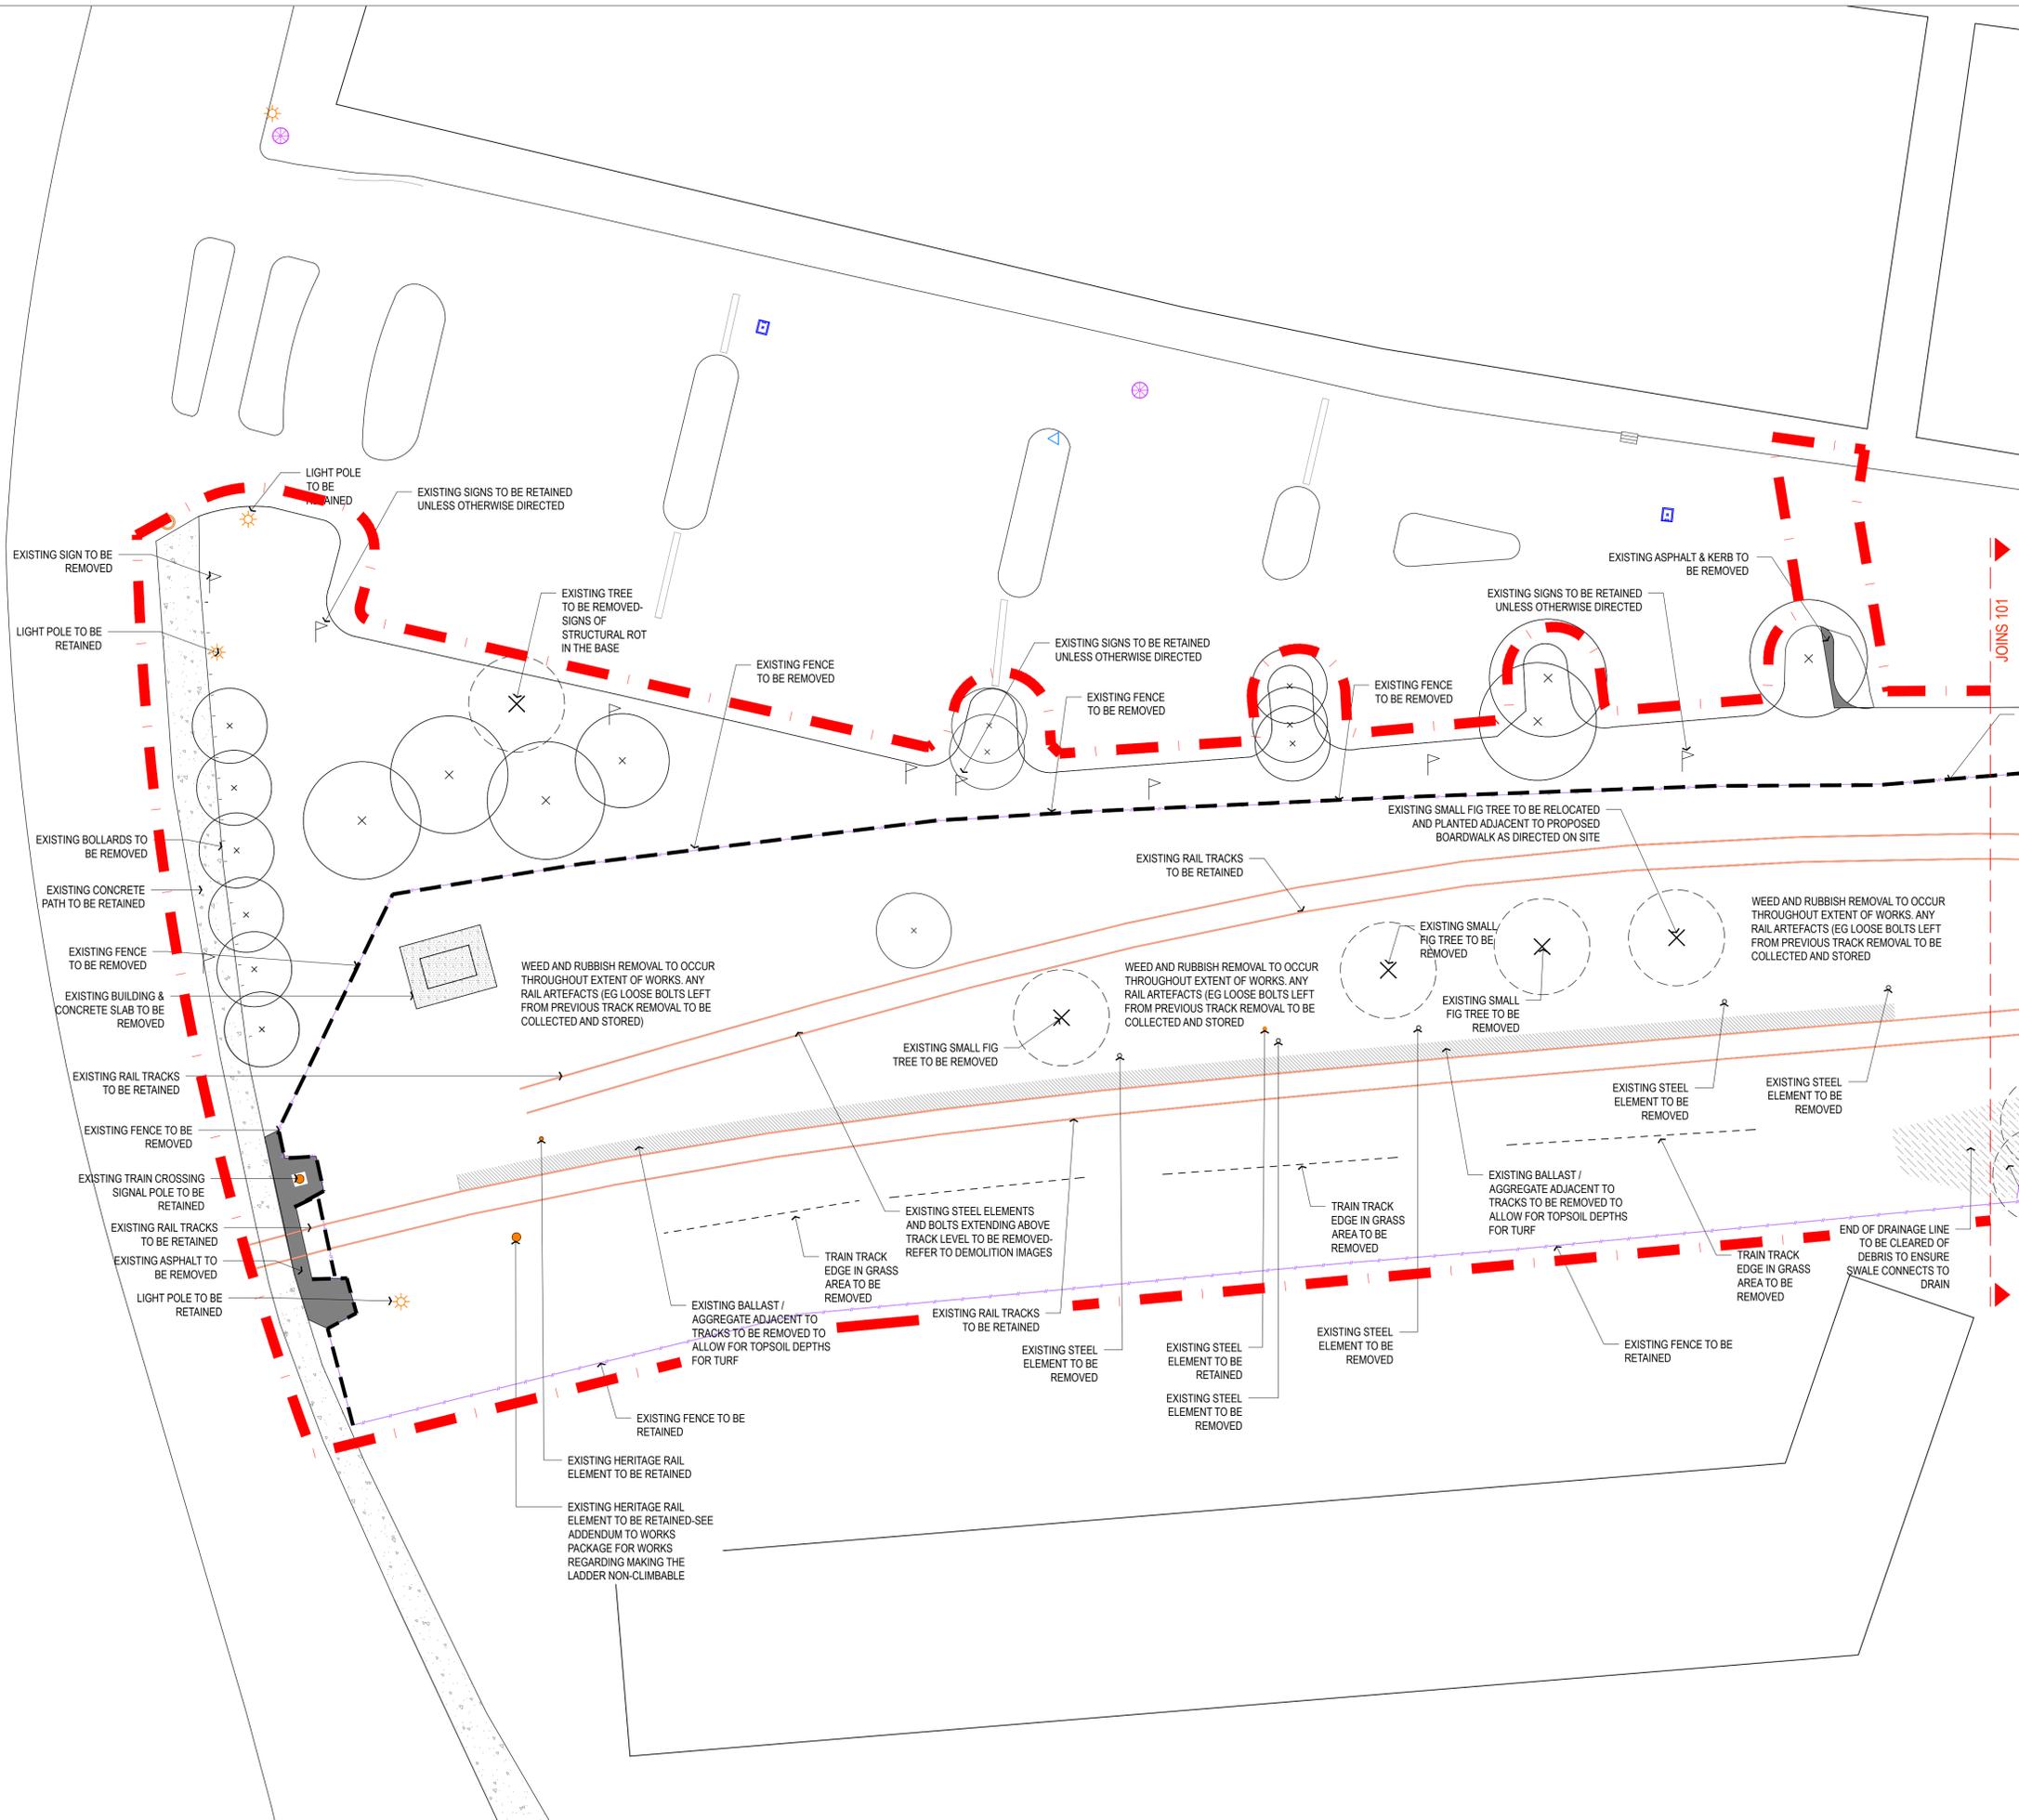

Revision	Description	Date	Initial
B	FOR TENDER	31.07.20	
A	FINAL DRAFT FOR REVIEW	19.06.20	


1:200 @ A1

PLUMMER & SMITH
 landscape architecture / art / design
 abn: 17 634 944 737 m 0437 599 011
 po box 204 e dsn@plummerandsmith.com.au
 murrumbidgee NSW 2484 w plummerandsmith.com.au
 © Copyright

BYRON SHIRE COUNCIL
 RAIL CORRIDOR PARK

DEMOLITION PLAN

Designed	DP	Drawn	EC
Checked	DP	Approved	
Date	19.06.2020	Scale	1:200
Job No.	211	Drawing No.	100
Revision			B

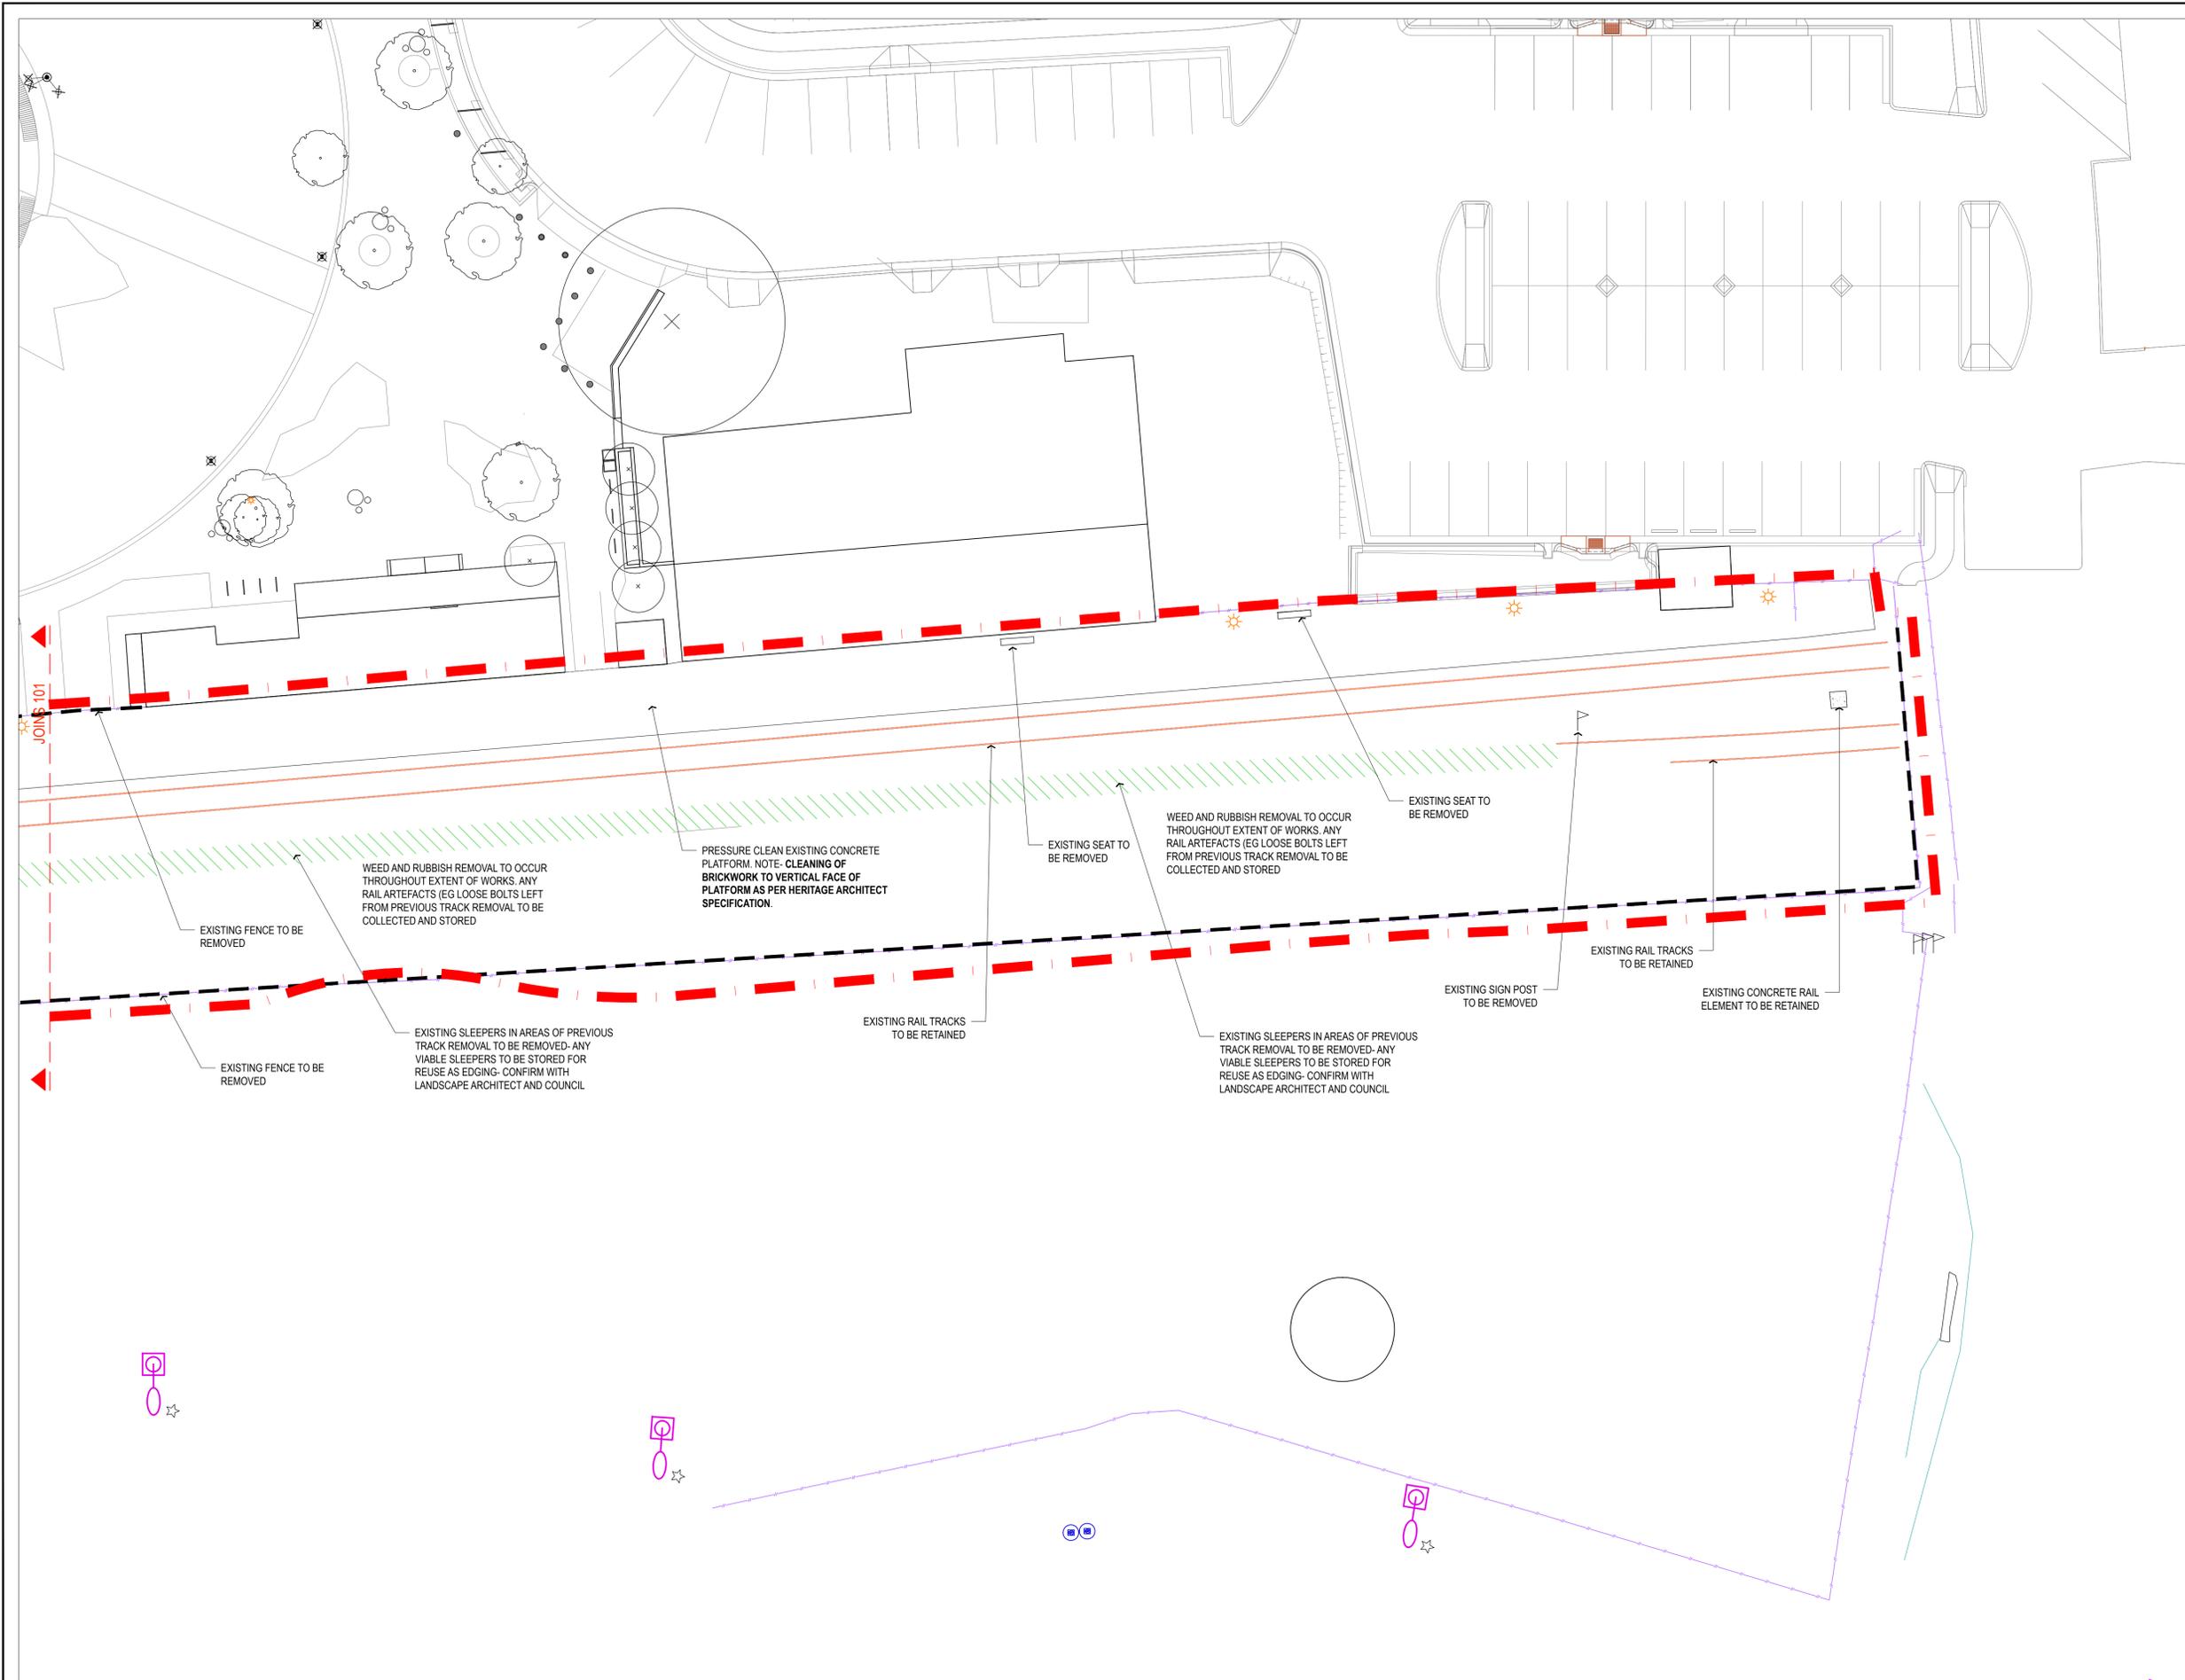

JOINS 101

WEED AND RUBBISH REMOVAL TO OCCUR THROUGHOUT EXTENT OF WORKS. ANY RAIL ARTEFACTS (EG LOOSE BOLTS LEFT FROM PREVIOUS TRACK REMOVAL TO BE COLLECTED AND STORED

PRESSURE CLEAN EXISTING CONCRETE PLATFORM. NOTE- CLEANING OF BRICKWORK TO VERTICAL FACE OF PLATFORM AS PER HERITAGE ARCHITECT SPECIFICATION.

WEED AND RUBBISH REMOVAL TO OCCUR THROUGHOUT EXTENT OF WORKS. ANY RAIL ARTEFACTS (EG LOOSE BOLTS LEFT FROM PREVIOUS TRACK REMOVAL TO BE COLLECTED AND STORED

EXISTING SLEEPERS IN AREAS OF PREVIOUS TRACK REMOVAL TO BE REMOVED- ANY VIABLE SLEEPERS TO BE STORED FOR REUSE AS EDGING- CONFIRM WITH LANDSCAPE ARCHITECT AND COUNCIL

EXISTING SLEEPERS IN AREAS OF PREVIOUS TRACK REMOVAL TO BE REMOVED- ANY VIABLE SLEEPERS TO BE STORED FOR REUSE AS EDGING- CONFIRM WITH LANDSCAPE ARCHITECT AND COUNCIL

Revision	Description	Date	Initial
B	FOR TENDER	31.07.20	
A	FINAL DRAFT FOR REVIEW	19.06.20	

1:200 @ A1


PLUMMER & SMITH
 landscape architecture / art / design
 abn: 17 634 944 737 m 0437 599 011
 po box 204 e dsn@plummerandsmith.com.au
 murwillumbah NSW 2484 w plummerandsmith.com.au
 © Copyright

BYRON SHIRE COUNCIL
RAIL CORRIDOR PARK

DEMOLITION PLAN

Designed DP	Drawn EC
Checked DP	Approved
Date 19.06.2020	Scale 1:200
Job No. 211	Drawing No. 102 Revision B



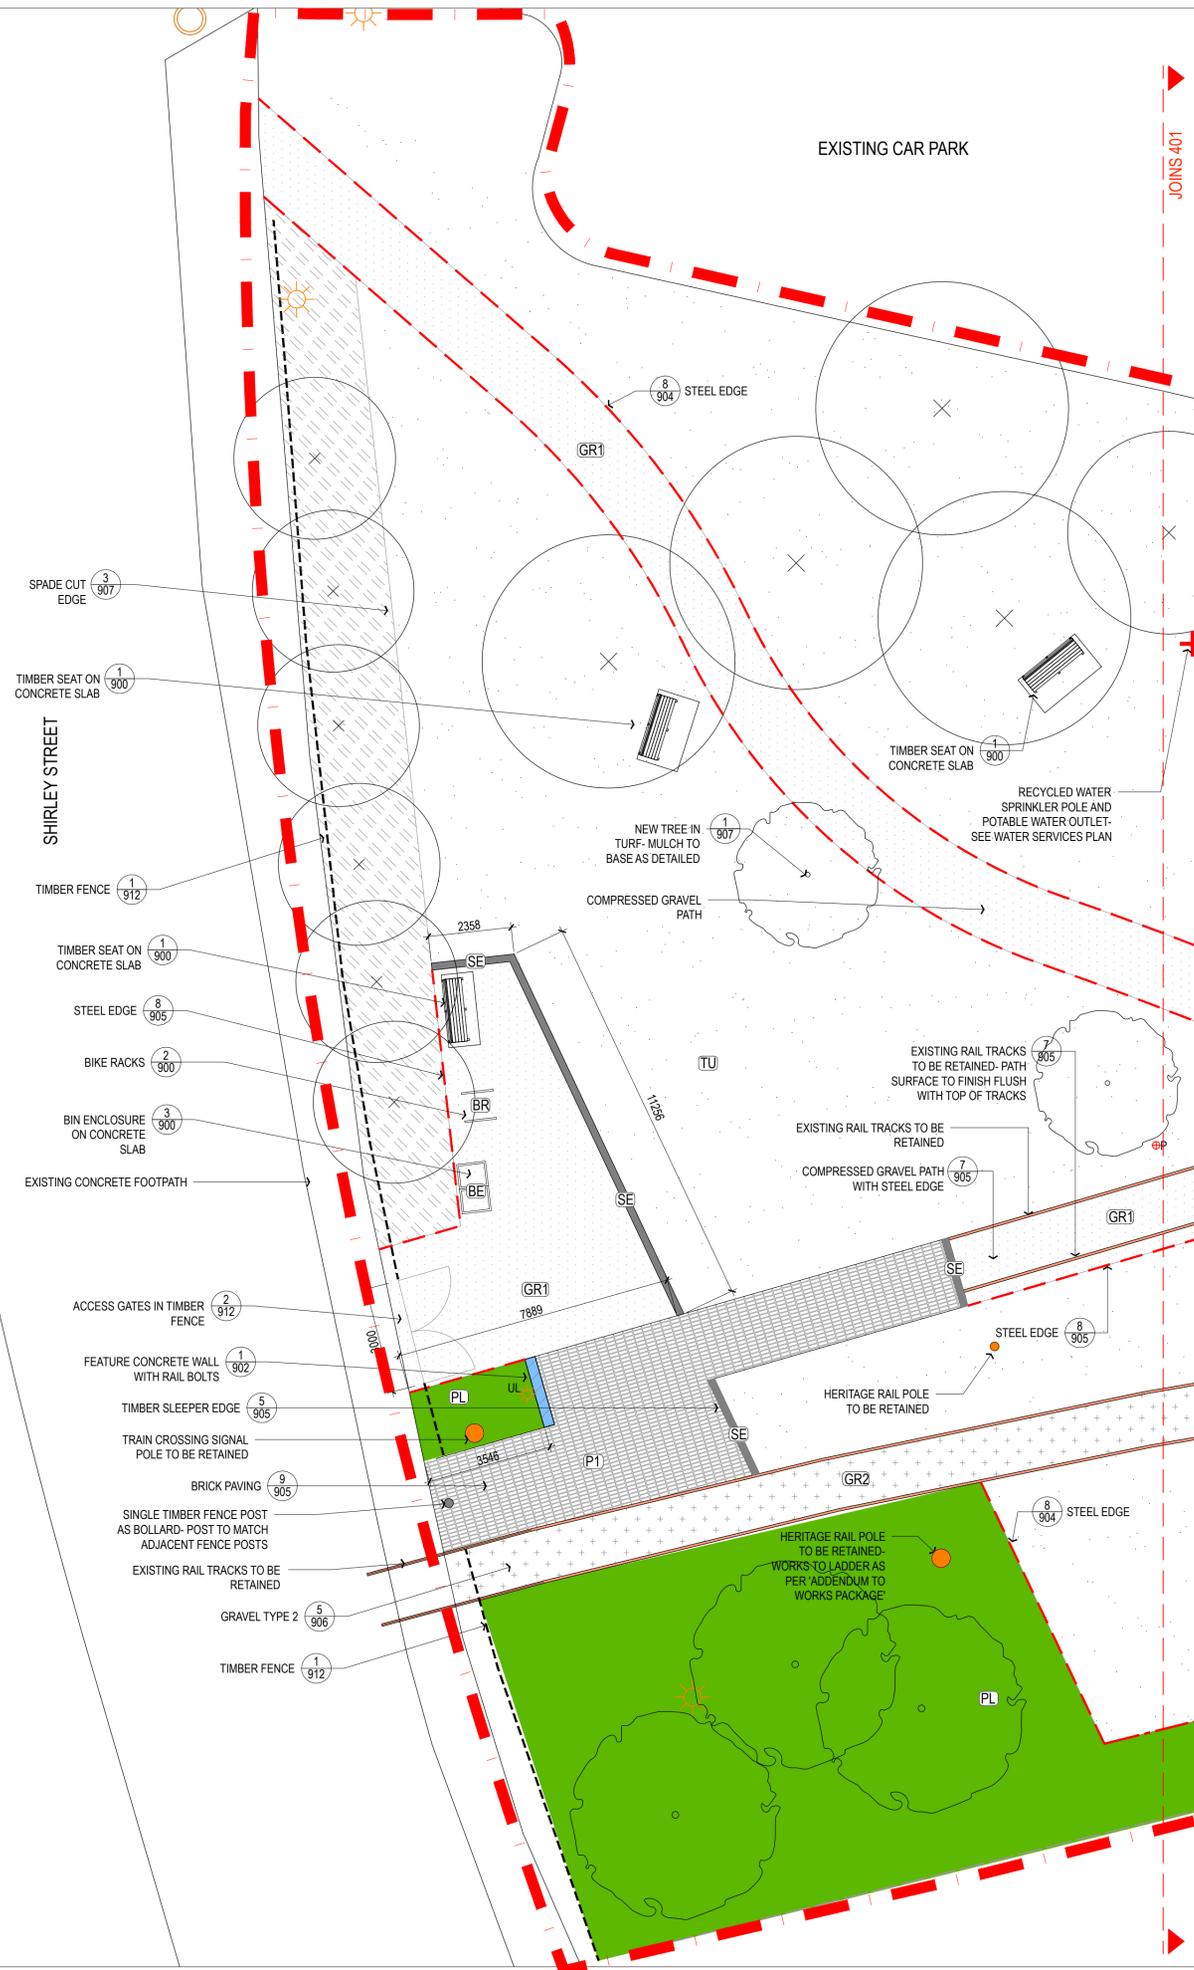

KEY

[Red dashed line]	EXTENT OF WORKS
[Red solid line]	EXISTING RAIL TRACKS TO BE RETAINED
[Orange line]	EXISTING RAIL ELEMENT TO BE RETAINED
[GR1]	COMPRESSED GRAVEL
[GR2]	GRAVEL INFILL TO TRACK AREA- REFER SCHED. OF MATERIALS AND FINISHES
[P1]	BRICK PAVING
[C1, C2]	CONCRETE
[C1, C2]	CONCRETE WALL
[GP1]	GRAVEL & PLANTING
[1, 911]	APPLIED FINISH TO EXISTING ASPHALT
[BM]	BOARWALK - COMPOSITE MESH
[BT]	BOARWALK - TIMBER
[8, 905]	STEEL EDGE
[182, 910]	BALUSTRADE
[SE]	TIMBER SLEEPER EDGE
[TU]	TURF
[PL]	PLANTING AREA. REFER TO SOFTWARES PLAN
[Light pole symbol]	LIGHT-POLE MULTI-HEAD. REFER TO LIGHTING/ ELECTRICAL DWG'S
[Light pole symbol]	LIGHT-POLE LUMINAIRE. REFER TO LIGHTING/ ELECTRICAL DWG'S
[Light pole symbol]	UP LIGHT. REFER TO LIGHTING/ ELECTRICAL DWG'S
[Power outlet symbol]	POWER OUTLET BOLLARD. REFER TO LIGHTING/ ELECTRICAL DWG'S
[Bin enclosure symbol]	BIN ENCLOSURE
[Bike rack symbol]	BIKE RACK
[Timber seat symbol]	TIMBER SEAT
[Timber bench seat symbol]	TIMBER BENCH SEAT
[Custom timber seat symbol]	CUSTOM TIMBER SEAT
[Drinking fountain symbol]	DRINKING FOUNTAIN / WATER REFILL STATION
[Feature timber post symbol]	FEATURE TIMBER POST / INTERPRETATION PANEL
[Feature boulder symbol]	FEATURE BOULDER
[Tree planting symbol]	TREE PLANTING
[Existing tree symbol]	EXISTING TREE TO REMAIN

NOTE- SET OUT TO BE COMPLETED BY SURVEYOR. SITE REVIEW SURVEYED SET OUT WITH LANDSCAPE ARCHITECT PRIOR TO CONSTRUCTION WORKS COMMENCING

NOTE- THESE WORKS ARE IN A HERITAGE LISTED SITE. EXISTING ARTEFACTS ARE TO BE RETAINED UNLESS EXPLICITLY NOTED OTHERWISE. SEEK APPROVAL PRIOR TO THE DISTURBANCE OF ANY RAIL INFRASTRUCTURE

Revision	Description	Date	Initial
C	FOR TENDER	31.07.20	
B	FINAL DRAFT FOR REVIEW	19.06.20	
A	PRELIMINARY- FOR INFORMATION ONLY	25.05.20	

1:100 @ A1


PLUMMER & SMITH
 landscape architecture / art / design
 abn: 17 534 944 737 m 0437 599 011
 po box 204 e dcn@plummerandsmith.com.au
 murrumbidgee NSW 2484 w plummerandsmith.com.au
 © Copyright

BYRON SHIRE COUNCIL

RAIL CORRIDOR PARK

HARDWORKS & EARTHWORKS PLANS

Designed DP	Drawn EC
Checked DP	Approved
Date 25.05.2020	Scale 1:100
Job No. 211	Drawing No. 400
	Revision C

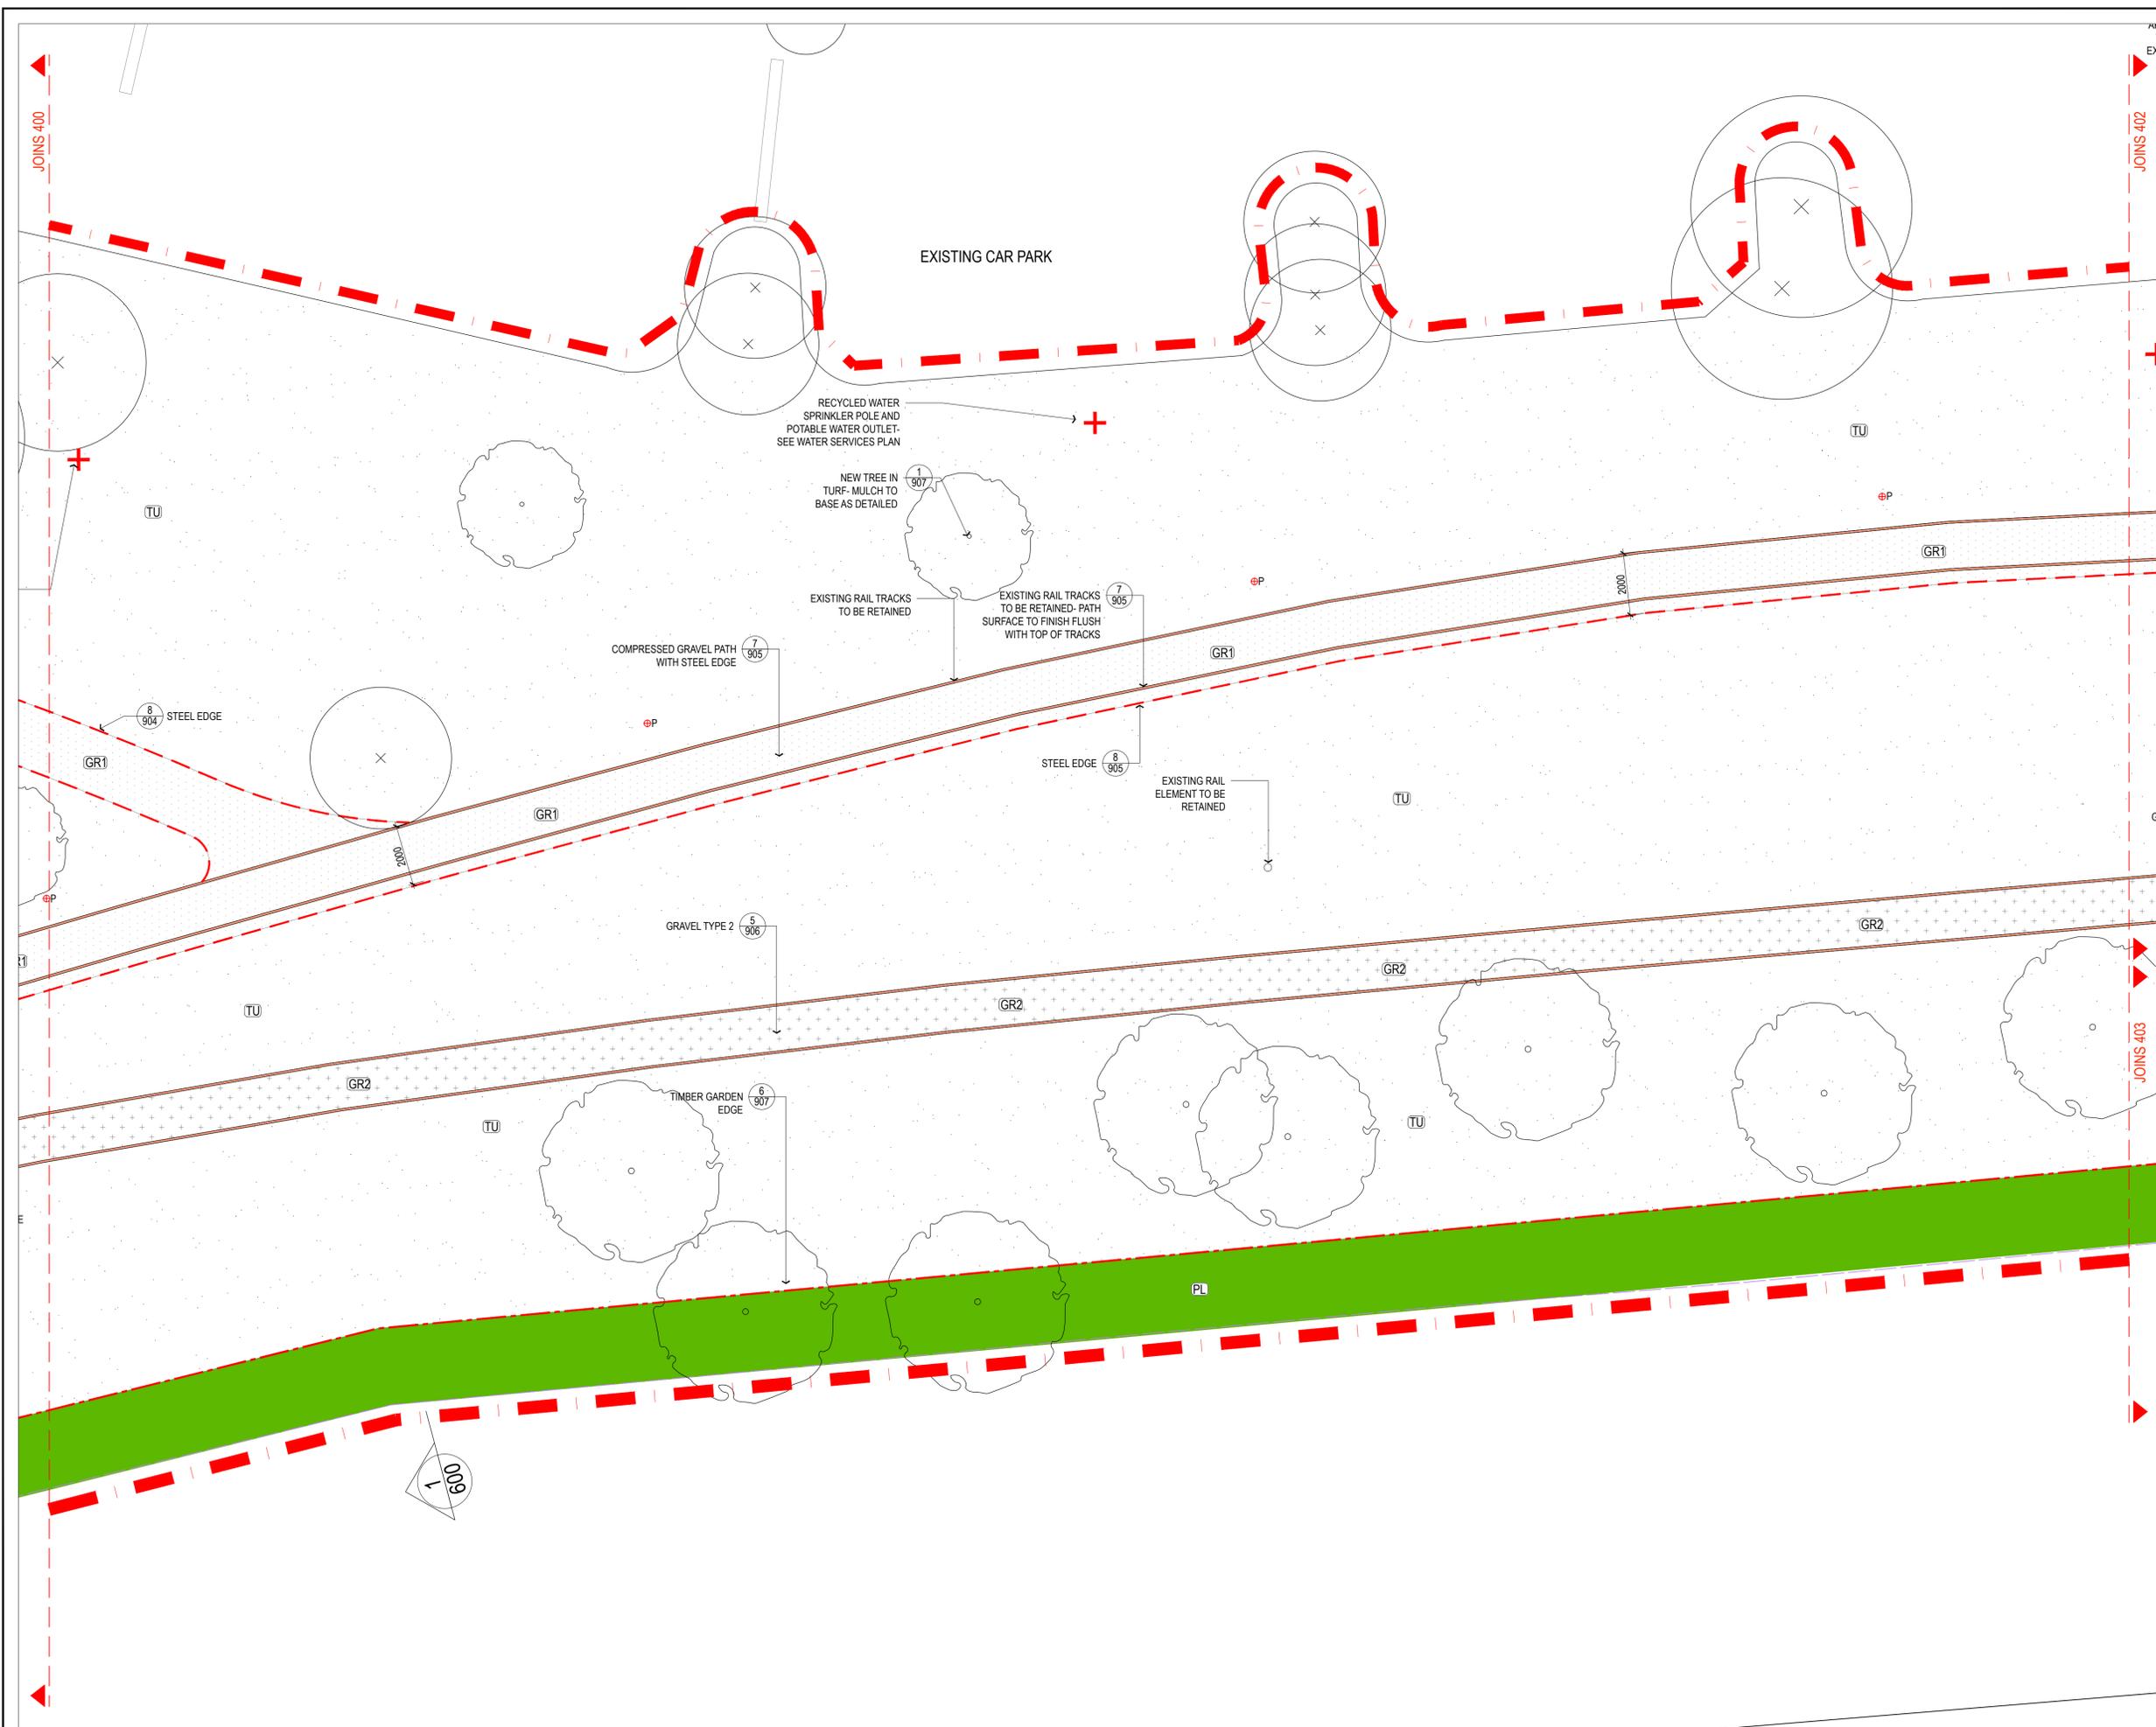

- KEY**
- EXTENT OF WORKS
 - EXISTING RAIL TRACKS TO BE RETAINED
 - EXISTING RAIL ELEMENT TO BE RETAINED
 - COMPRESSED GRAVEL
 - GRAVEL INFILL TO TRACK AREA- REFER SCHED. OF MATERIALS AND FINISHES
 - BRICK PAVING
 - CONCRETE
 - CONCRETE WALL
 - GRAVEL & PLANTING
 - APPLIED FINISH TO EXISTING ASPHALT
 - BOARWALK - COMPOSITE MESH
 - BOARWALK - TIMBER
 - STEEL EDGE
 - BALUSTRADE
 - TIMBER SLEEPER EDGE
 - TURF
 - PLANTING AREA. REFER TO SOFTWARES PLAN
 - LIGHT-POLE MULTI-HEAD. REFER TO LIGHTING/ ELECTRICAL DWG'S
 - LIGHT-POLE LUMINAIRE. REFER TO LIGHTING/ ELECTRICAL DWG'S
 - UP LIGHT. REFER TO LIGHTING/ ELECTRICAL DWG'S
 - POWER OUTLET BOLLARD. REFER TO LIGHTING/ ELECTRICAL DWG'S
 - BIN ENCLOSURE
 - BIKE RACK
 - TIMBER SEAT
 - TIMBER BENCH SEAT
 - CUSTOM TIMBER SEAT
 - DRINKING FOUNTAIN / WATER REFILL STATION
 - FEATURE TIMBER POST / INTERPRETATION PANEL
 - FEATURE BOULDER
 - TREE PLANTING
 - EXISTING TREE TO REMAIN

NOTE- SET OUT TO BE COMPLETED BY SURVEYOR. SITE REVIEW SURVEYED SET OUT WITH LANDSCAPE ARCHITECT PRIOR TO CONSTRUCTION WORKS COMMENCING

NOTE- THESE WORKS ARE IN A HERITAGE LISTED SITE. EXISTING ARTIFACTS ARE TO BE RETAINED UNLESS EXPLICITLY NOTED OTHERWISE. SEEK APPROVAL PRIOR TO THE DISTURBANCE OF ANY RAIL INFRASTRUCTURE

Revision	Description	Date	Initial
C	FOR TENDER	31.07.20	
B	FINAL DRAFT FOR REVIEW	19.06.20	
A	PRELIMINARY- FOR INFORMATION ONLY	25.05.20	

1:100 @ A1


PLUMMER & SMITH
 landscape architecture / art / design
 abn: 17 634 944 737 m 0437 599 011
 po box 204 e dsn@plummerandsmith.com.au
 murwillumbah NSW 2484 w plummerandsmith.com.au
 © Copyright

BYRON SHIRE COUNCIL

RAIL CORRIDOR PARK

HARDWORKS & EARTHWORKS PLANS

Designed	DP	Drawn	EC
Checked	DP	Approved	
Date	25.05.2020	Scale	1:100
Job No.	211	Drawing No.	401
		Revision	C

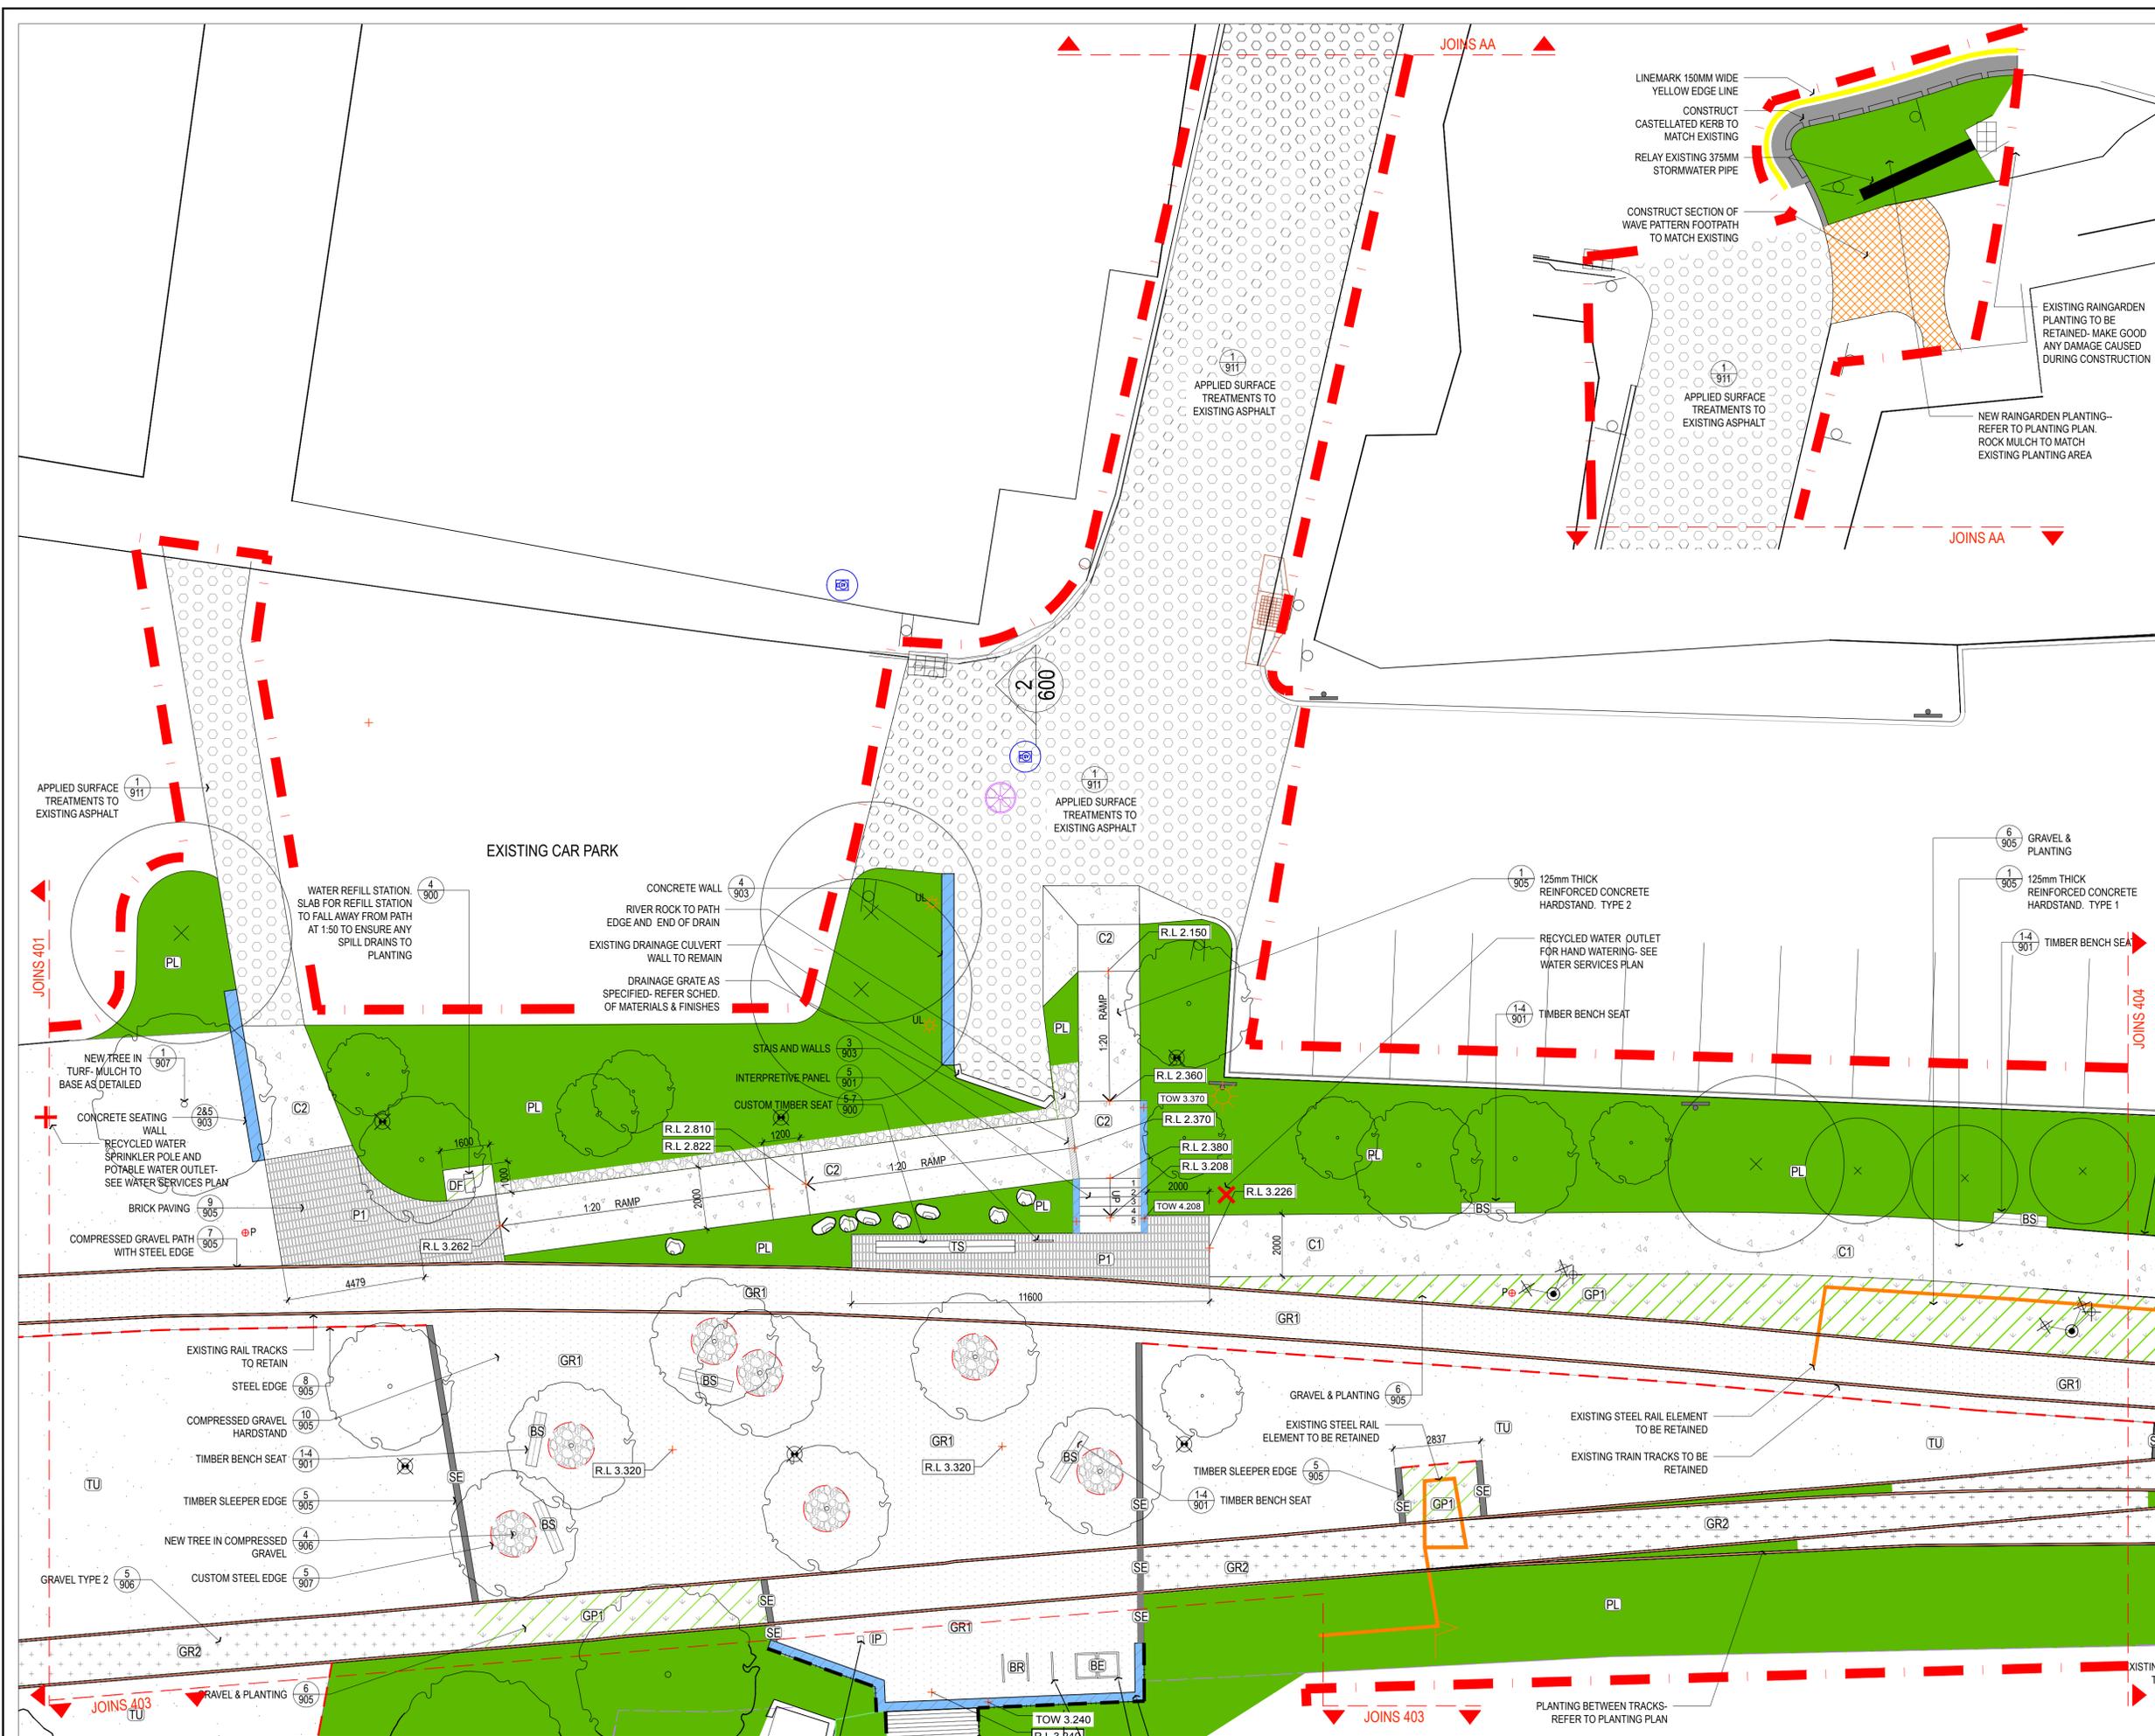

- KEY**
- [Red dashed line] EXTENT OF WORKS
 - [Black line] EXISTING RAIL TRACKS TO BE RETAINED
 - [Orange hatched] EXISTING RAIL ELEMENT TO BE RETAINED
 - [GR1] COMPRESSED GRAVEL
 - [GR2] GRAVEL INFILL TO TRACK AREA- REFER SCHED. OF MATERIALS AND FINISHES
 - [P1] BRICK PAVING
 - [C1] CONCRETE
 - [C2] CONCRETE WALL
 - [GP1] GRAVEL & PLANTING
 - [911] APPLIED FINISH TO EXISTING ASPHALT
 - [BM] BOARWALK - COMPOSITE MESH
 - [BT] BOARWALK - TIMBER
 - [8] STEEL EDGE
 - [182/910] BALUSTRADE
 - [5/905] TIMBER SLEEPER EDGE
 - [TU] TURF
 - [PL] PLANTING AREA. REFER TO SOFTWORKS PLAN
 - [Light pole symbol] LIGHT-POLE MULTI-HEAD. REFER TO LIGHTING/ ELECTRICAL DWG'S
 - [Luminaire symbol] LIGHT-POLE LUMINAIRE. REFER TO LIGHTING/ ELECTRICAL DWG'S
 - [Up light symbol] UP LIGHT. REFER TO LIGHTING/ ELECTRICAL DWG'S
 - [Power outlet symbol] POWER OUTLET BOLLARD. REFER TO LIGHTING/ ELECTRICAL DWG'S
 - [BE] BIN ENCLOSURE
 - [BR] BIKE RACK
 - [TS] TIMBER SEAT
 - [1-4/901] TIMBER BENCH SEAT
 - [5-7/900] CUSTOM TIMBER SEAT
 - [4/900] DRINKING FOUNTAIN / WATER REFILL STATION
 - [5/901] FEATURE TIMBER POST / INTERPRETATION PANEL
 - [4/907] FEATURE BOULDER
 - [184/906] TREE PLANTING
 - [Circle with cross] EXISTING TREE TO REMAIN

NOTE- SET OUT TO BE COMPLETED BY SURVEYOR. SITE REVIEW SURVEYED SET OUT WITH LANDSCAPE ARCHITECT PRIOR TO CONSTRUCTION WORKS COMMENCING

NOTE- THESE WORKS ARE IN A HERITAGE LISTED SITE. EXISTING ARTEFACTS ARE TO BE RETAINED UNLESS EXPLICITLY NOTED OTHERWISE. SEEK APPROVAL PRIOR TO THE DISTURBANCE OF ANY RAIL INFRASTRUCTURE

Revision	Description	Date	Initial
C	FOR TENDER	31.07.20	
B	FINAL DRAFT FOR REVIEW	19.06.20	
A	PRELIMINARY- FOR INFORMATION ONLY	25.05.20	

1:100 @ A1

PLUMMER & SMITH
 landscape architecture / art / design
 abn: 17 634 944 737 m 0437 599 011
 po box 204 e dsm@plummerandsmith.com.au
 murwillumbah NSW 2484 w plummerandsmith.com.au
 © Copyright

BYRON SHIRE COUNCIL
RAIL CORRIDOR PARK

HARDWORKS & EARTHWORKS PLANS

Designed DP	Drawn EC
Checked DP	Approved
Date 25.05.2020	Scale 1:100
Job No. 211	Drawing No. 402
	Revision C



- KEY**
- EXTENT OF WORKS
 - EXISTING RAIL TRACKS TO BE RETAINED
 - EXISTING RAIL ELEMENT TO BE RETAINED
 - GR3 10/905 COMPRESSED GRAVEL
 - GR2 5/906 GRAVEL INFILL TO TRACK AREA- REFER SCHED. OF MATERIALS AND FINISHES
 - GP1 9/905 BRICK PAVING
 - C2 1/905 CONCRETE
 - C2 902/903-04 CONCRETE WALL
 - GP1 6/905 GRAVEL & PLANTING
 - 1/911 APPLIED FINISH TO EXISTING ASPHALT
 - 2/908-09 BOARWALK - COMPOSITE MESH
 - 1/908-09 BOARWALK - TIMBER
 - 8/905 STEEL EDGE
 - 1&2/910 BALUSTRADE
 - 5/905 TIMBER SLEEPER EDGE
 - TU 3/906 TURF
 - 2/906 PLANTING AREA. REFER TO SOFTWORKS PLAN
 - LIGHT-POLE MULTI-HEAD. REFER TO LIGHTING/ ELECTRICAL DWG'S
 - LIGHT-POLE LUMINAIRE. REFER TO LIGHTING/ ELECTRICAL DWG'S
 - UP LIGHT. REFER TO LIGHTING/ ELECTRICAL DWG'S
 - POWER OUTLET BOLLARD. REFER TO LIGHTING/ ELECTRICAL DWG'S
 - 3/900 BIN ENCLOSURE
 - 2/900 BIKE RACK
 - 1/900 TIMBER SEAT
 - 1-4/901 TIMBER BENCH SEAT
 - 5-7/900 CUSTOM TIMBER SEAT
 - 4/900 DRINKING FOUNTAIN / WATER REFILL STATION
 - 5/901 FEATURE TIMBER POST / INTERPRETATION PANEL
 - 4/907 FEATURE BOULDER
 - 1&4/906 1/907 TREE PLANTING
 - EXISTING TREE TO REMAIN

NOTE- SET OUT TO BE COMPLETED BY SURVEYOR. SITE REVIEW SURVEYED SET OUT WITH LANDSCAPE ARCHITECT PRIOR TO CONSTRUCTION WORKS COMMENCING

NOTE- THESE WORKS ARE IN A HERITAGE LISTED SITE. EXISTING ARTEFACTS ARE TO BE RETAINED UNLESS EXPLICITLY NOTED OTHERWISE. SEEK APPROVAL PRIOR TO THE DISTURBANCE OF ANY RAIL INFRASTRUCTURE

Revision	Description	Date	Initial
C	FOR TENDER	31.07.20	
B	FINAL DRAFT FOR REVIEW	19.06.20	
A	PRELIMINARY- FOR INFORMATION ONLY	25.05.20	


1:100 @ A1

PLUMMER & SMITH
 landscape architecture / art / design
 abn: 17 634 944 737 m 0437 599 011
 po box 204 e dsn@plummerandsmith.com.au
 murrumbidgee NSW 2484 w plummerandsmith.com.au
 © Copyright

BYRON SHIRE COUNCIL
 RAIL CORRIDOR PARK

HARDWORKS & EARTHWORKS PLANS

Designed DP	Drawn EC
Checked DP	Approved
Date 25.05.2020	Scale 1:100
Job No. 211	Drawing No. 403
	Revision C

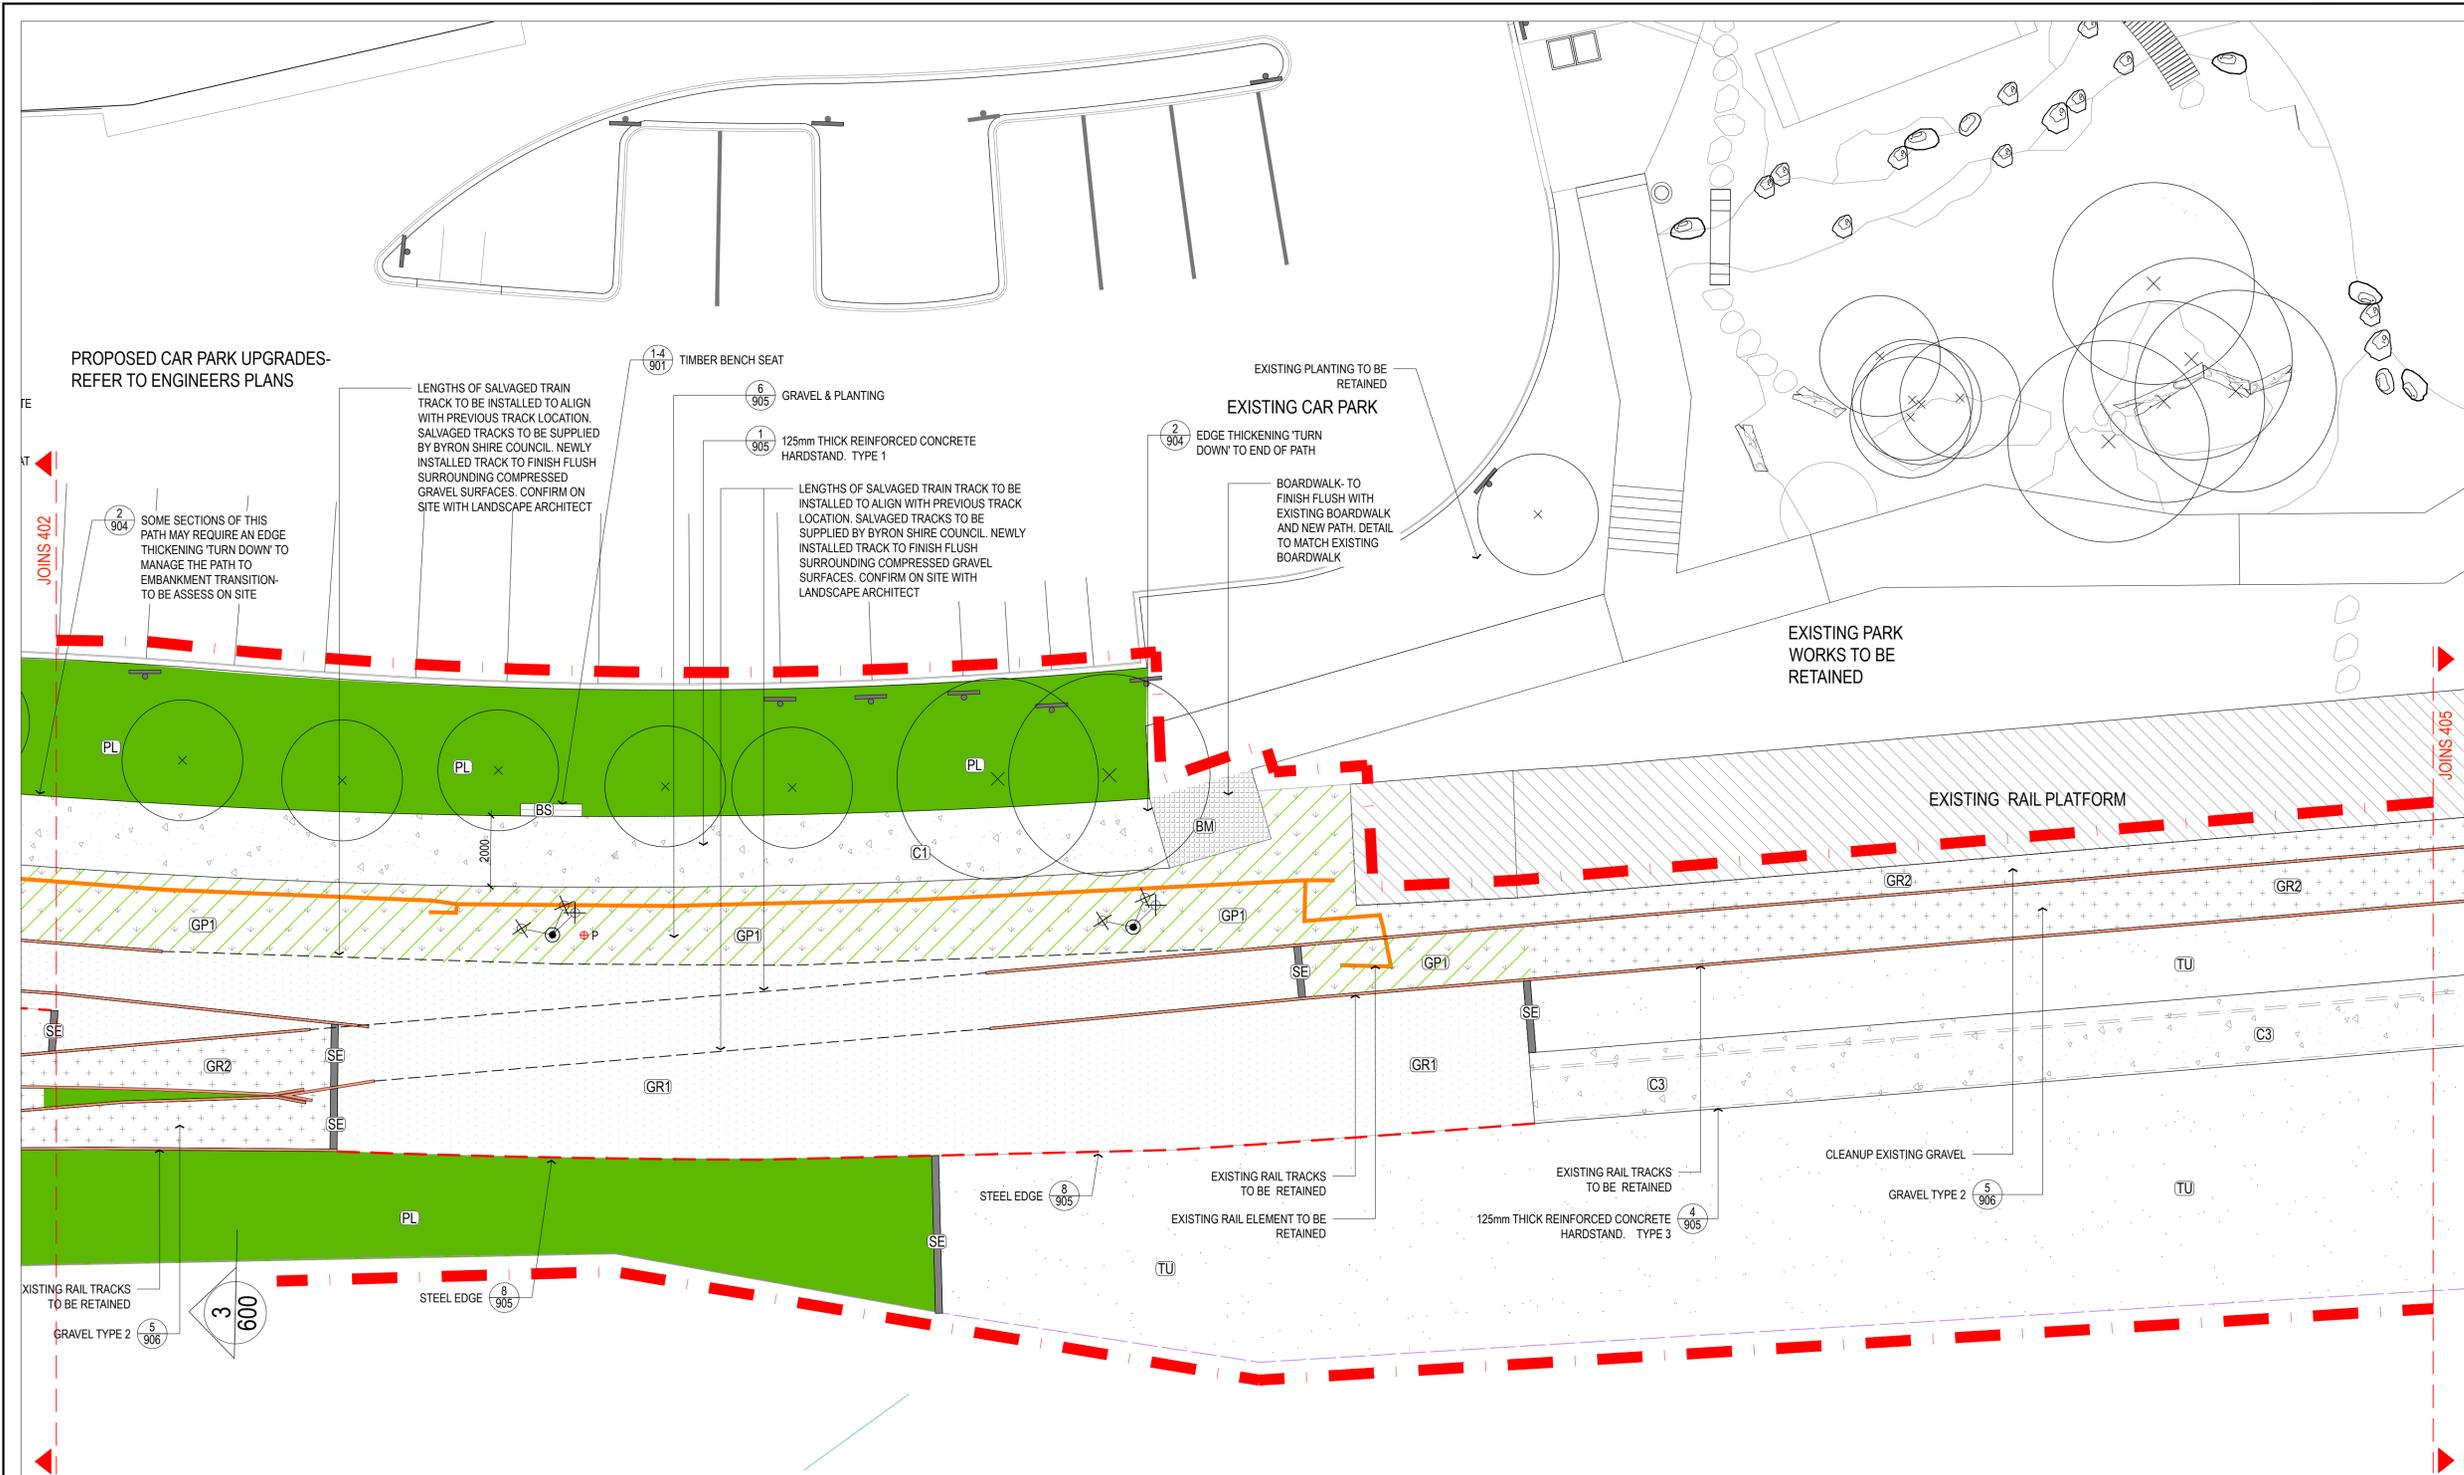

- KEY**
- EXTENT OF WORKS
 - EXISTING RAIL TRACKS TO BE RETAINED
 - EXISTING RAIL ELEMENT TO BE RETAINED
 - GR1 10/905 COMPRESSED GRAVEL
 - GR2 5/906 GRAVEL INFILL TO TRACK AREA- REFER SCHED. OF MATERIALS AND FINISHES
 - P1 9/905 BRICK PAVING
 - C1, C2, C3 1/905 CONCRETE
 - C1, C2, C3 902/903-04 CONCRETE WALL
 - GP1 6/905 GRAVEL & PLANTING
 - 1/911 APPLIED FINISH TO EXISTING ASPHALT
 - BM 2/908-09 BOARWALK - COMPOSITE MESH
 - BT 2/908-09 BOARWALK - TIMBER
 - 8/905 STEEL EDGE
 - 1&2/910 BALUSTRADE
 - 5/905 TIMBER SLEEPER EDGE
 - TU 3/906 TURF
 - PL 2/906 PLANTING AREA. REFER TO SOFTWORKS PLAN
 - LIGHT-POLE MULTI-HEAD. REFER TO LIGHTING/ELECTRICAL DWG'S
 - LIGHT-POLE LUMINAIRE. REFER TO LIGHTING/ELECTRICAL DWG'S
 - UP LIGHT. REFER TO LIGHTING/ELECTRICAL DWG'S
 - POWER OUTLET BOLLARD. REFER TO LIGHTING/ELECTRICAL DWG'S
 - BE 3/900 BIN ENCLOSURE
 - BR 2/900 BIKE RACK
 - TS 1/900 TIMBER SEAT
 - TB 1-4/901 TIMBER BENCH SEAT
 - CS 5-7/900 CUSTOM TIMBER SEAT
 - DF 4/900 DRINKING FOUNTAIN / WATER REFILL STATION
 - FT 5/901 FEATURE TIMBER POST / INTERPRETATION PANEL
 - FB 4/907 FEATURE BOULDER
 - TP 1&4/906 1/907 TREE PLANTING
 - EXISTING TREE TO REMAIN

NOTE- SET OUT TO BE COMPLETED BY SURVEYOR. SITE REVIEW SURVEYED SET OUT WITH LANDSCAPE ARCHITECT PRIOR TO CONSTRUCTION WORKS COMMENCING

NOTE- THESE WORKS ARE IN A HERITAGE LISTED SITE. EXISTING ARTEFACTS ARE TO BE RETAINED UNLESS EXPLICITLY NOTED OTHERWISE. SEEK APPROVAL PRIOR TO THE DISTURBANCE OF ANY RAIL INFRASTRUCTURE

Revision	Description	Date	Initial
C	FOR TENDER	31.07.20	
B	FINAL DRAFT FOR REVIEW	19.06.20	
A	PRELIMINARY- FOR INFORMATION ONLY	25.05.20	


1:100 @ A1

PLUMMER & SMITH
 landscape architecture / art / design
 abn: 17 634 944 737 m 0437 599 011
 po box 204 e dar@plummerandsmith.com.au
 murwillumbah NSW 2484 w plummerandsmith.com.au
 © Copyright

BYRON SHIRE COUNCIL
RAIL CORRIDOR PARK

HARDWORKS & EARTHWORKS PLANS

Designed DP	Drawn EC
Checked DP	Approved
Date 25.05.2020	Scale 1:100
Job No. 211	Drawing No. 404 Revision C

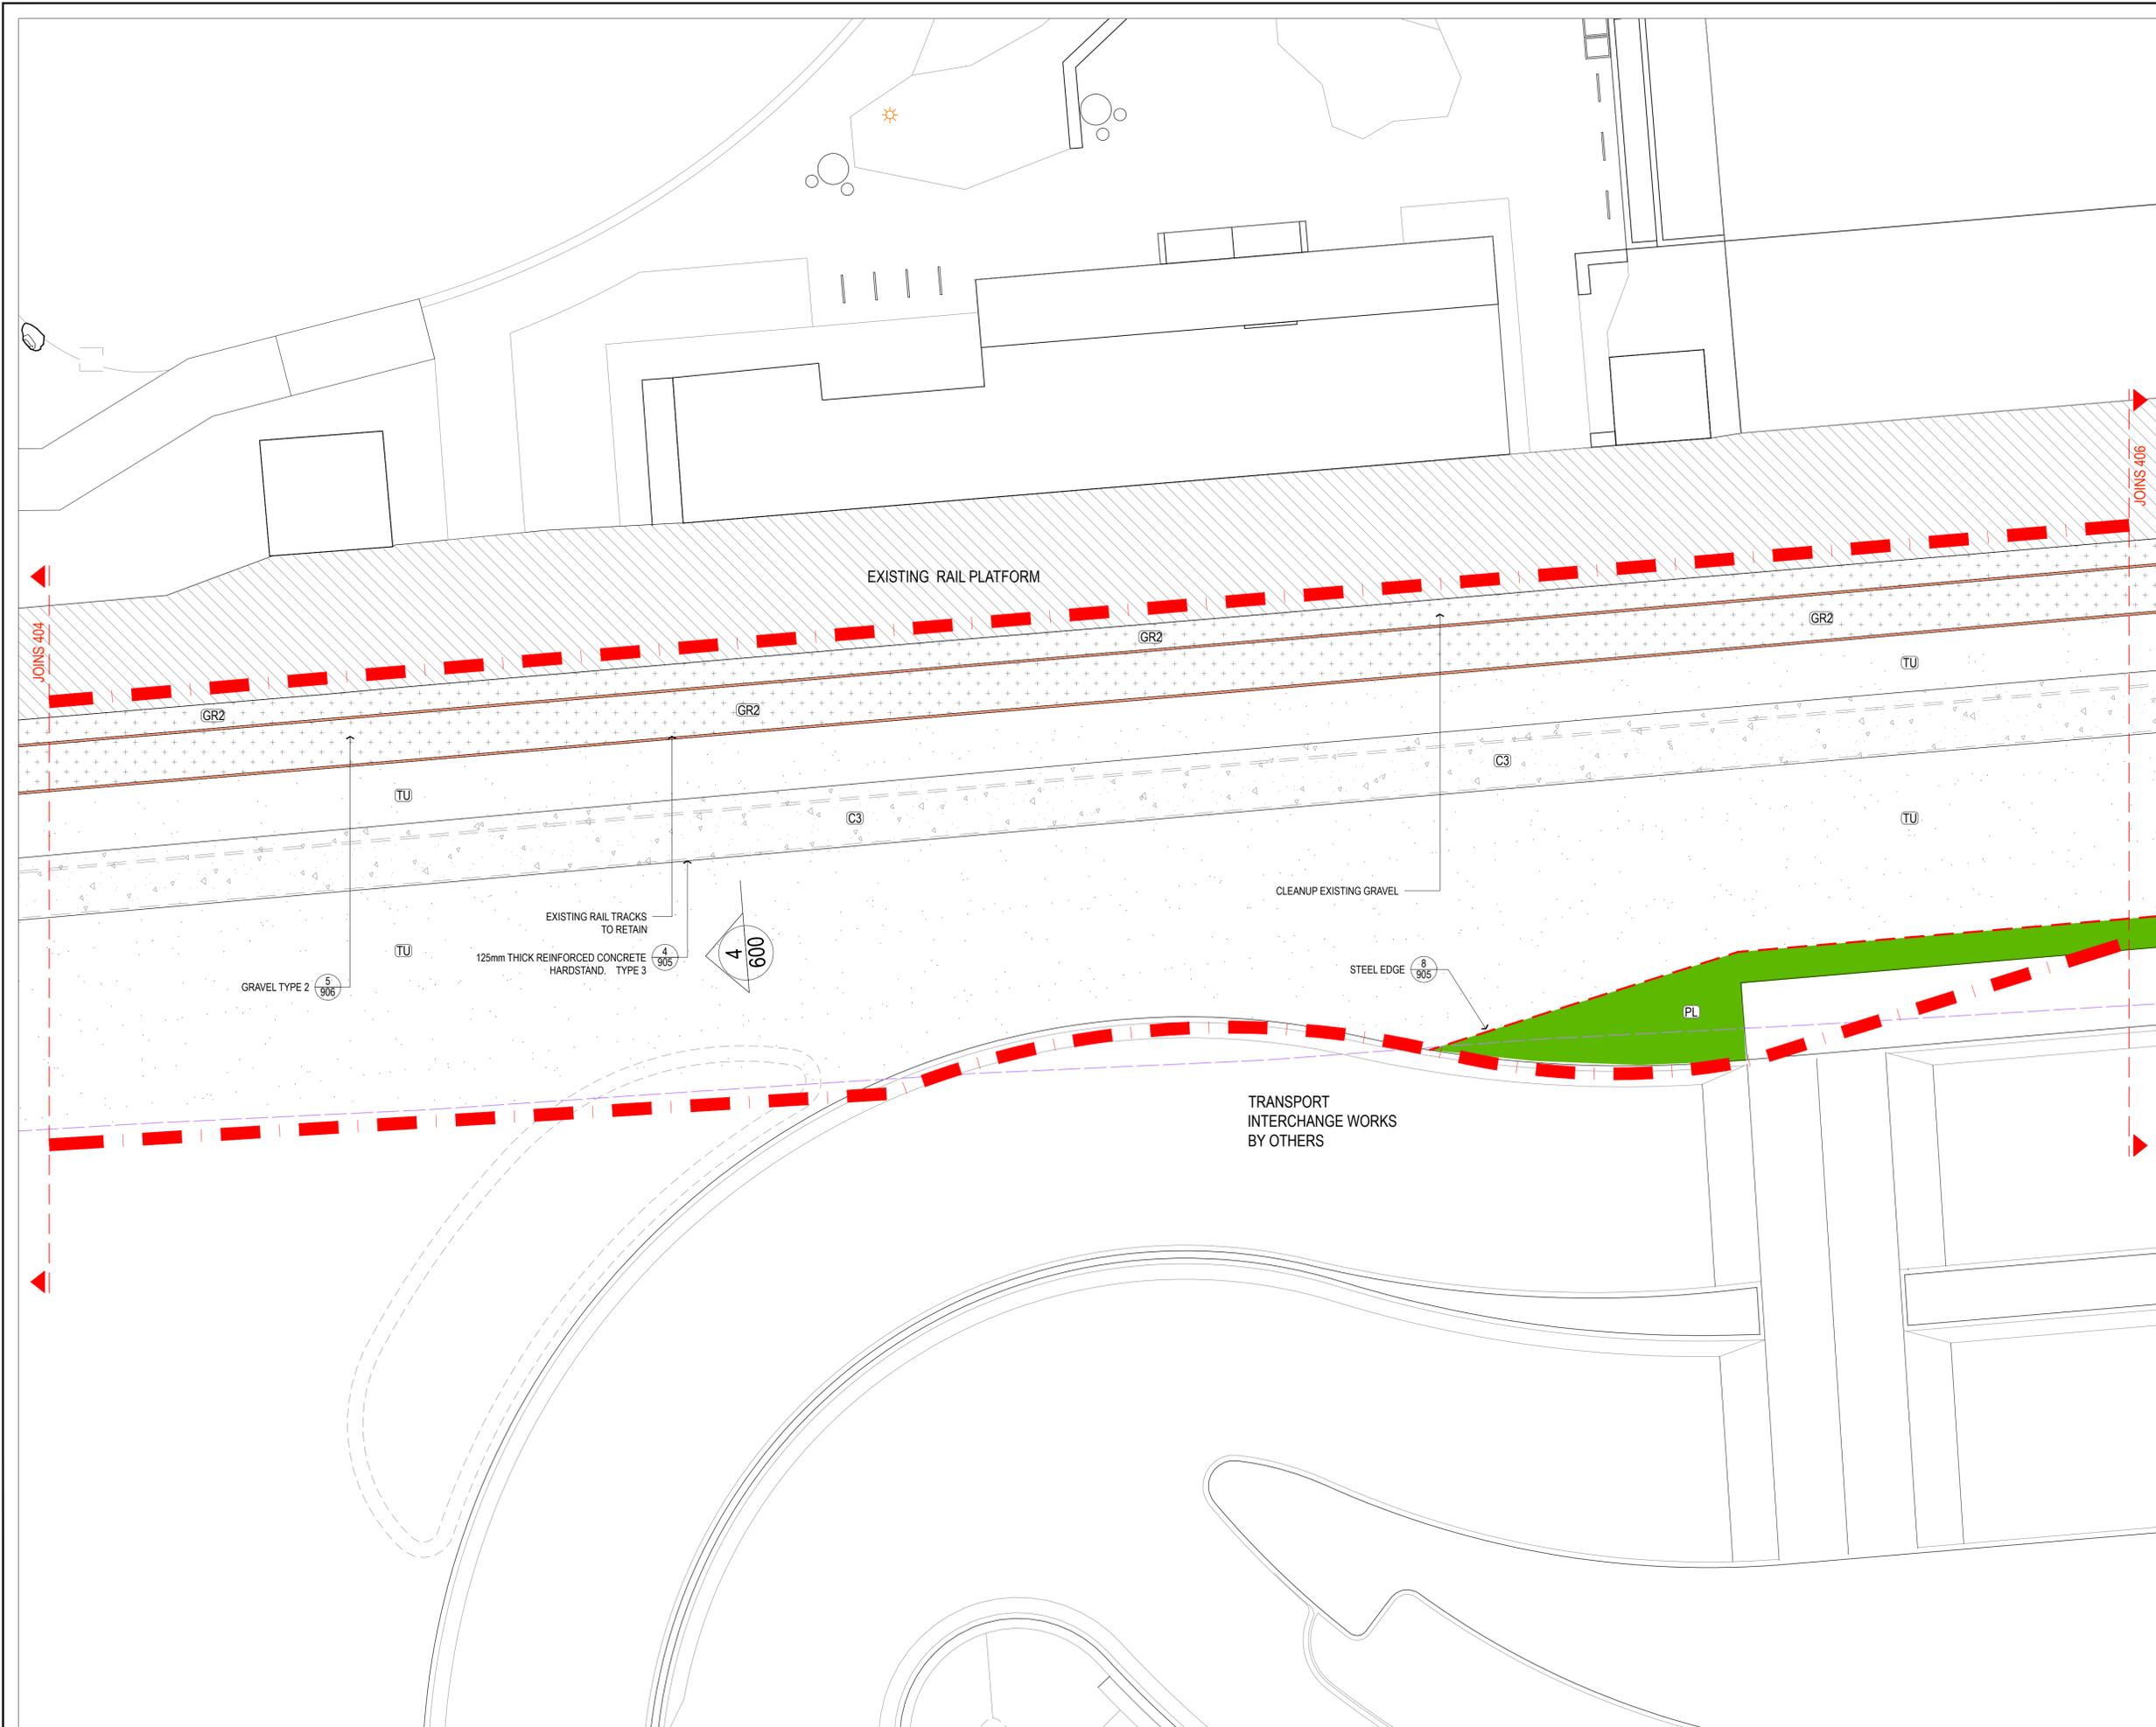

- KEY**
- EXTENT OF WORKS
 - EXISTING RAIL TRACKS TO BE RETAINED
 - EXISTING RAIL ELEMENT TO BE RETAINED
 - GR1 COMPRESSED GRAVEL
 - GR2 GRAVEL INFILL TO TRACK AREA- REFER SCHED. OF MATERIALS AND FINISHES
 - P1 BRICK PAVING
 - C1 C2 C3 CONCRETE
 - C02 C03 C04 CONCRETE WALL
 - GP1 GRAVEL & PLANTING
 - 1 911 APPLIED FINISH TO EXISTING ASPHALT
 - 2 908-09 BOARWALK - COMPOSITE MESH
 - 1 908-09 BOARWALK - TIMBER
 - 8 905 STEEL EDGE
 - 1&2 910 BALUSTRADE
 - 5 905 TIMBER SLEEPER EDGE
 - 3 906 TURF
 - PL PLANTING AREA. REFER TO SOFTWORKS PLAN
 - L LIGHT-POLE MULTI-HEAD. REFER TO LIGHTING/ ELECTRICAL DWG'S
 - L LIGHT-POLE LUMINAIRE. REFER TO LIGHTING/ ELECTRICAL DWG'S
 - L UP LIGHT. REFER TO LIGHTING/ ELECTRICAL DWG'S
 - P POWER OUTLET BOLLARD. REFER TO LIGHTING/ ELECTRICAL DWG'S
 - 3 900 BIN ENCLOSURE
 - 2 900 BIKE RACK
 - 1 900 TIMBER SEAT
 - 1-4 901 TIMBER BENCH SEAT
 - 5-7 900 CUSTOM TIMBER SEAT
 - 4 900 DRINKING FOUNTAIN / WATER REFILL STATION
 - 5 901 FEATURE TIMBER POST / INTERPRETATION PANEL
 - 4 907 FEATURE BOULDER
 - 1&4 906 TREE PLANTING
 - 1 907 EXISTING TREE TO REMAIN

NOTE- SET OUT TO BE COMPLETED BY SURVEYOR. SITE REVIEW SURVEYED SET OUT WITH LANDSCAPE ARCHITECT PRIOR TO CONSTRUCTION WORKS COMMENCING

NOTE- THESE WORKS ARE IN A HERITAGE LISTED SITE. EXISTING ARTEFACTS ARE TO BE RETAINED UNLESS EXPLICITLY NOTED OTHERWISE. SEEK APPROVAL PRIOR TO THE DISTURBANCE OF ANY RAIL INFRASTRUCTURE

C	FOR TENDER	31.07.20
B	FINAL DRAFT FOR REVIEW	19.06.20
A	PRELIMINARY- FOR INFORMATION ONLY	25.05.20

1:100 @ A1


PLUMMER & SMITH
 landscape architecture / art / design
 abn: 17 634 944 737 m 0437 599 011
 po box 204 e dsn@plummerandsmith.com.au
 murwillumbah NSW 2484 w plummerandsmith.com.au
 © Copyright

BYRON SHIRE COUNCIL

RAIL CORRIDOR PARK

HARDWORKS & EARTHWORKS PLANS

Designed	DP	Drawn	EC
Checked	DP	Approved	
Date	25.05.2020	Scale	1:100
Job No.	211	Drawing No.	405
		Revision	C

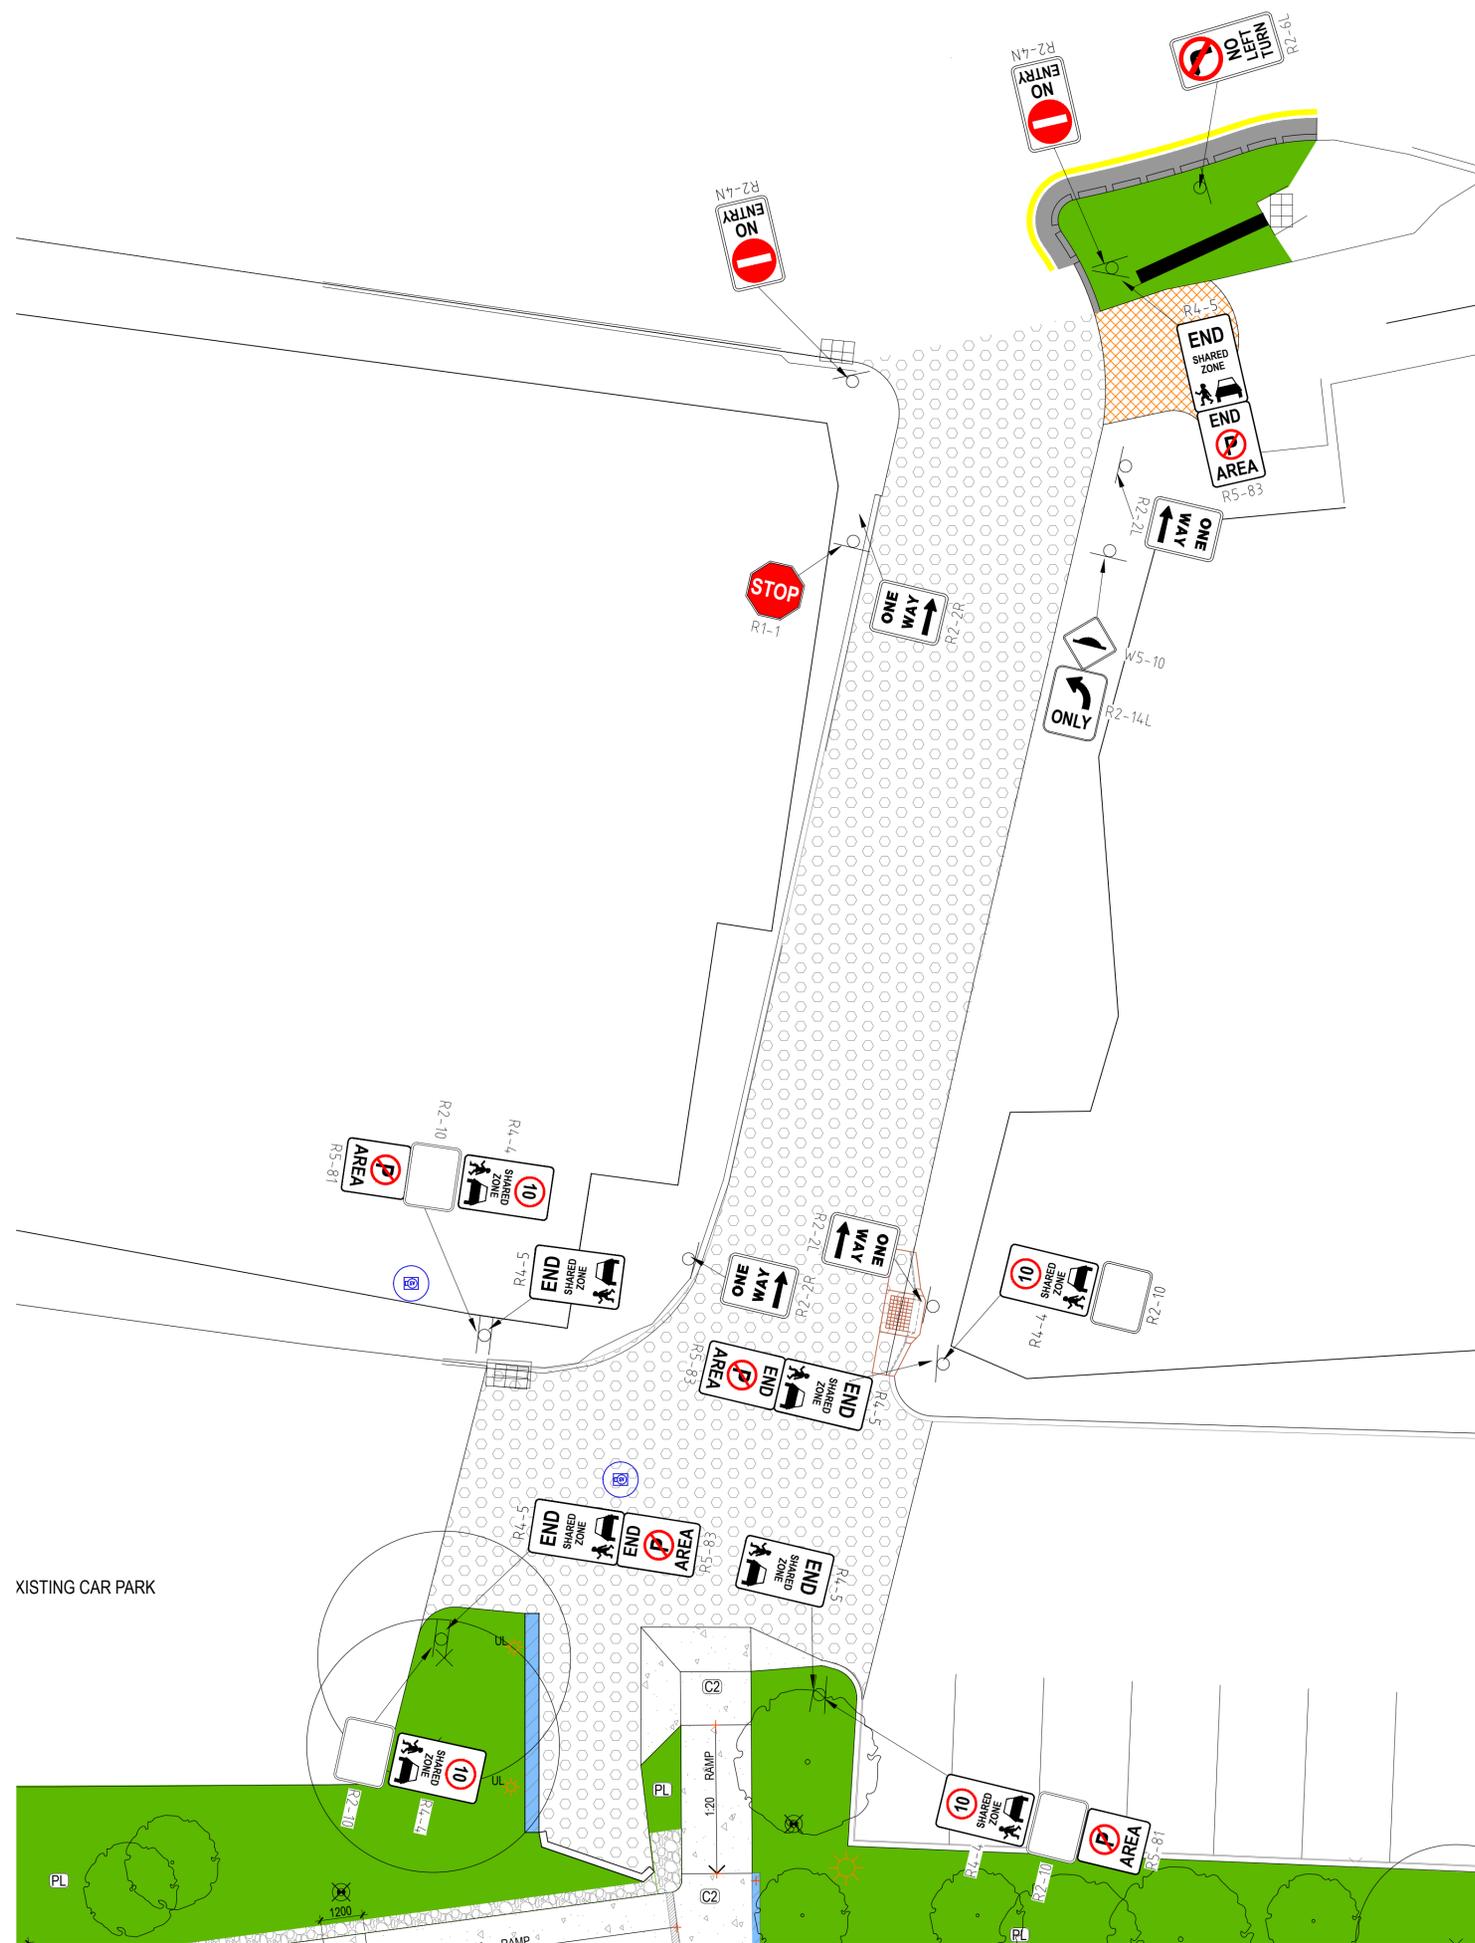

- KEY**
- EXTENT OF WORKS
 - EXISTING RAIL TRACKS TO BE RETAINED
 - EXISTING RAIL ELEMENT TO BE RETAINED
 - COMPRESSED GRAVEL
 - GRAVEL INFILL TO TRACK AREA- REFER SCHED. OF MATERIALS AND FINISHES
 - BRICK PAVING
 - CONCRETE
 - CONCRETE WALL
 - GRAVEL & PLANTING
 - APPLIED FINISH TO EXISTING ASPHALT
 - BOARWALK - COMPOSITE MESH
 - BOARWALK - TIMBER
 - STEEL EDGE
 - BALUSTRADE
 - TIMBER SLEEPER EDGE
 - TURF
 - PLANTING AREA. REFER TO SOFTWARES PLAN
 - LIGHT-POLE MULTI-HEAD. REFER TO LIGHTING/ ELECTRICAL DWG'S
 - LIGHT-POLE LUMINAIRE. REFER TO LIGHTING/ ELECTRICAL DWG'S
 - UP LIGHT. REFER TO LIGHTING/ ELECTRICAL DWG'S
 - POWER OUTLET BOLLARD. REFER TO LIGHTING/ ELECTRICAL DWG'S
 - BIN ENCLOSURE
 - BIKE RACK
 - TIMBER SEAT
 - TIMBER BENCH SEAT
 - CUSTOM TIMBER SEAT
 - DRINKING FOUNTAIN / WATER REFILL STATION
 - FEATURE TIMBER POST / INTERPRETATION PANEL
 - FEATURE BOULDER
 - TREE PLANTING
 - EXISTING TREE TO REMAIN

NOTE- SET OUT TO BE COMPLETED BY SURVEYOR. SITE REVIEW SURVEYED SET OUT WITH LANDSCAPE ARCHITECT PRIOR TO CONSTRUCTION WORKS COMMENCING

NOTE- THESE WORKS ARE IN A HERITAGE LISTED SITE. EXISTING ARTEFACTS ARE TO BE RETAINED UNLESS EXPLICITLY NOTED OTHERWISE. SEEK APPROVAL PRIOR TO THE DISTURBANCE OF ANY RAIL INFRASTRUCTURE

Revision	Description	Date	Initial
A	FOR TENDER	31.07.20	


1:100 @ A1

PLUMMER & SMITH
 landscape architecture / art / design
 abn: 17 634 944 737 m 0437 599 011
 po box 204 e dsn@plummerandsmith.com.au
 murwillumbah NSW 2484 w plummerandsmith.com.au
 © Copyright

BYRON SHIRE COUNCIL
RAIL CORRIDOR PARK

HARDWORKS- BYRON LANE SIGNAGE PLAN

Designed DP	Drawn EC
Checked DP	Approved
Date 31.07.2020	Scale 1:100
Job No. 211	Drawing No. 407
Revision	A

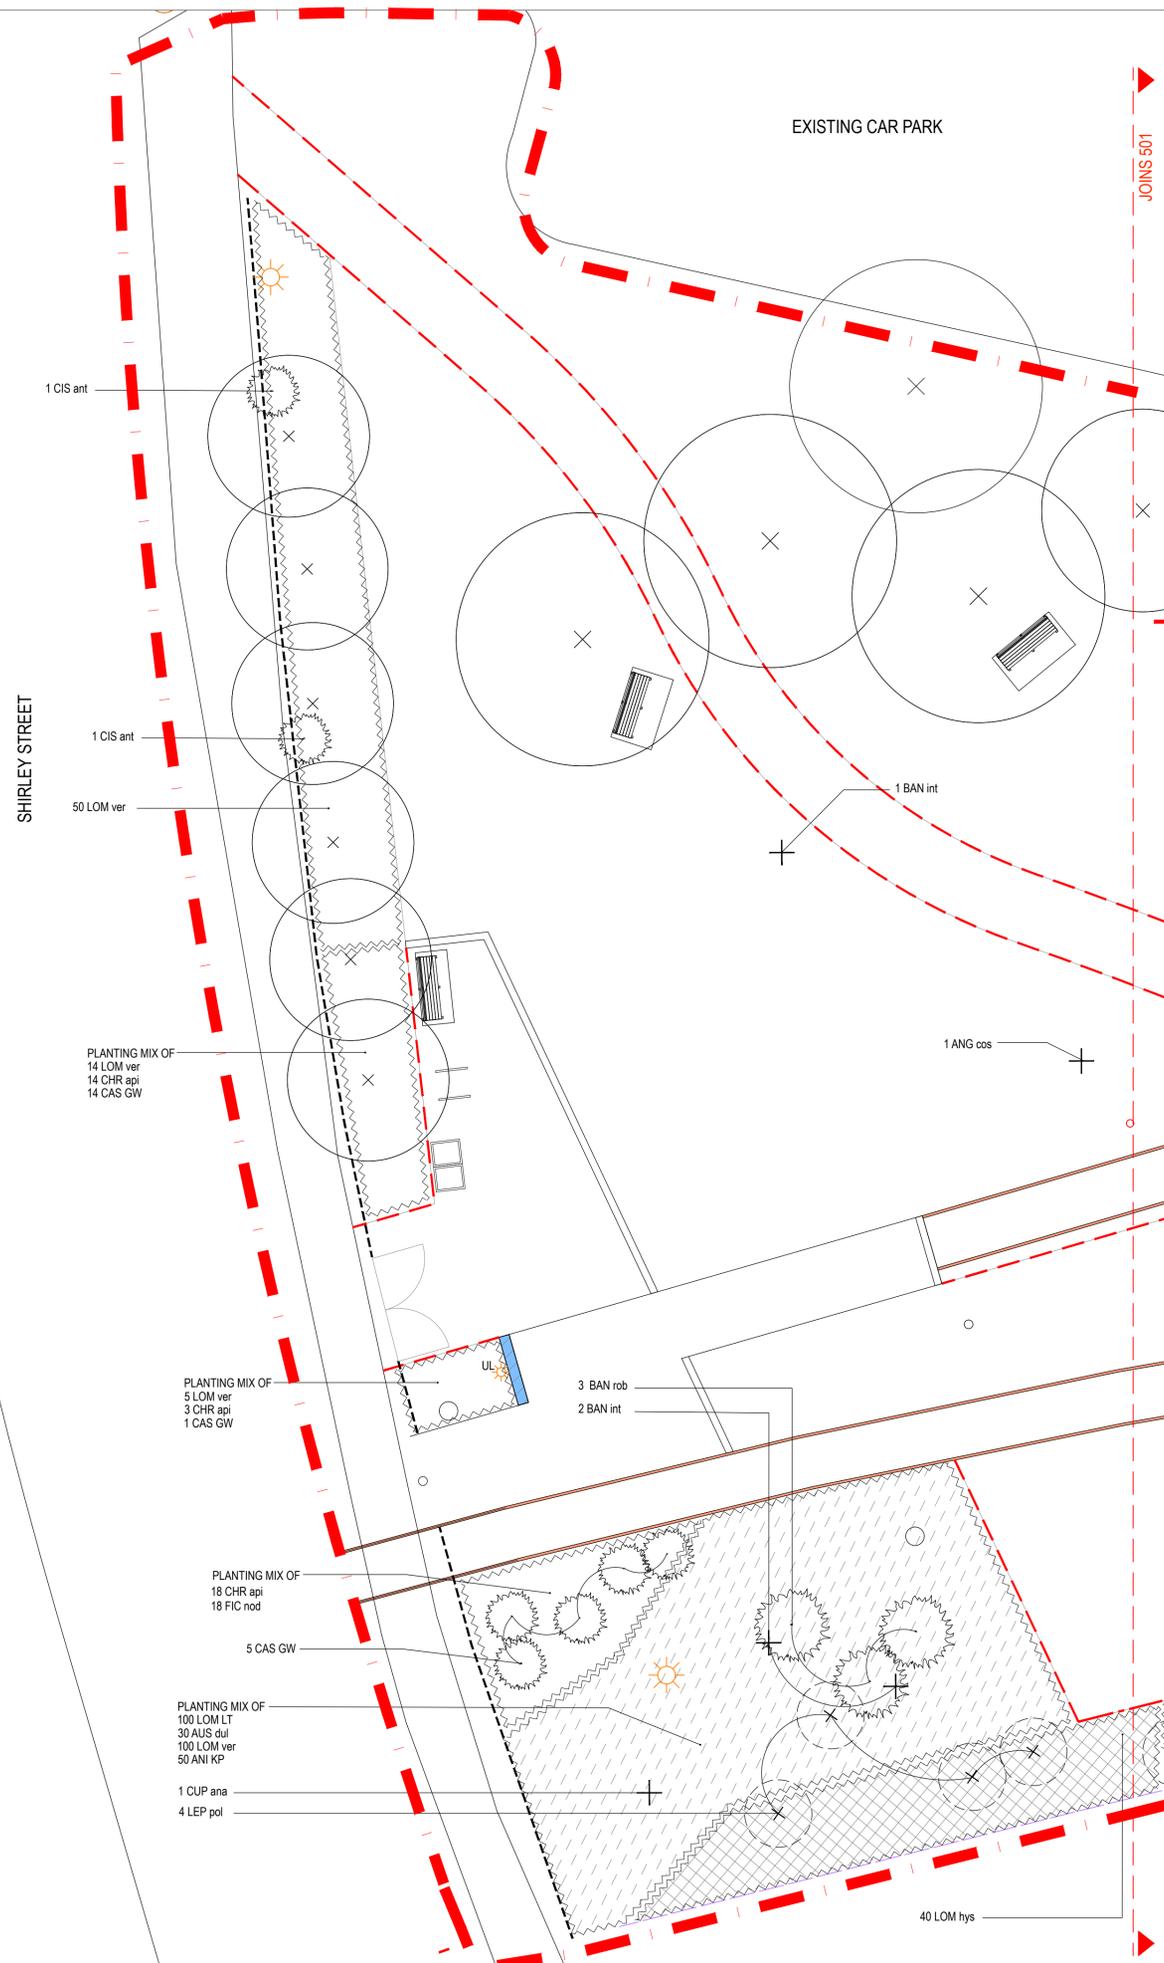

- KEY**
- EXISTING TREE TO BE RETAINED
 - TREE PLANTING
 - PALM PLANTING
 - SHRUBS AND FEATURE PLANTS- REFER TO PLANTING PLANS SCHEDULES.
 - SHRUBS AND FEATURE PLANTS- REFER TO PLANTING PLANS SCHEDULES.
 - HATCHED AND ZIG-ZAG BORDERED AREAS REPRESENT MASS PLANTING AREAS- REFER TO PLANTING PLANS AND PLANT SCHEDULES
 - ROOT BARRIER
 - CONCRETE WALL
 - EXTENT OF WORKS

- NOTES**
1. ENSURE ALL SERVICES ARE LOCATED PRIOR TO COMMENCING LANDSCAPE WORKS

NOTE- THESE WORKS ARE IN A HERITAGE LISTED SITE. EXISTING ARTEFACTS ARE TO BE RETAINED UNLESS EXPLICITLY NOTED OTHERWISE. SEEK APPROVAL PRIOR TO THE DISTURBANCE OF ANY RAIL INFRASTRUCTURE

Revision	Description	Date	Initial
B	FOR TENDER	31.07.20	
A	DRAFT - FOR REVIEW	19.06.20	

1:100 @ A1


PLUMMER & SMITH
 landscape architecture / art / design
 abn: 17 634 944 737 m 0437 599 011
 po box 204 e dlan@plummerandsmith.com.au
 murrumbidgee NSW 2484 w plummerandsmith.com.au
 © Copyright

BYRON SHIRE COUNCIL

RAIL CORRIDOR PARK

SOFTWORKS PLANS (SHEET 01 OF 07)

Designed DP	Drawn IW	(scanned signature here, preferably use a transparent jpg image. Layer order: jpg images to back if you must use one)
Checked DP	Approved	
Date 19.06.2020	Scale 1:100	
Job No. 211	Drawing No. 500	Revision B

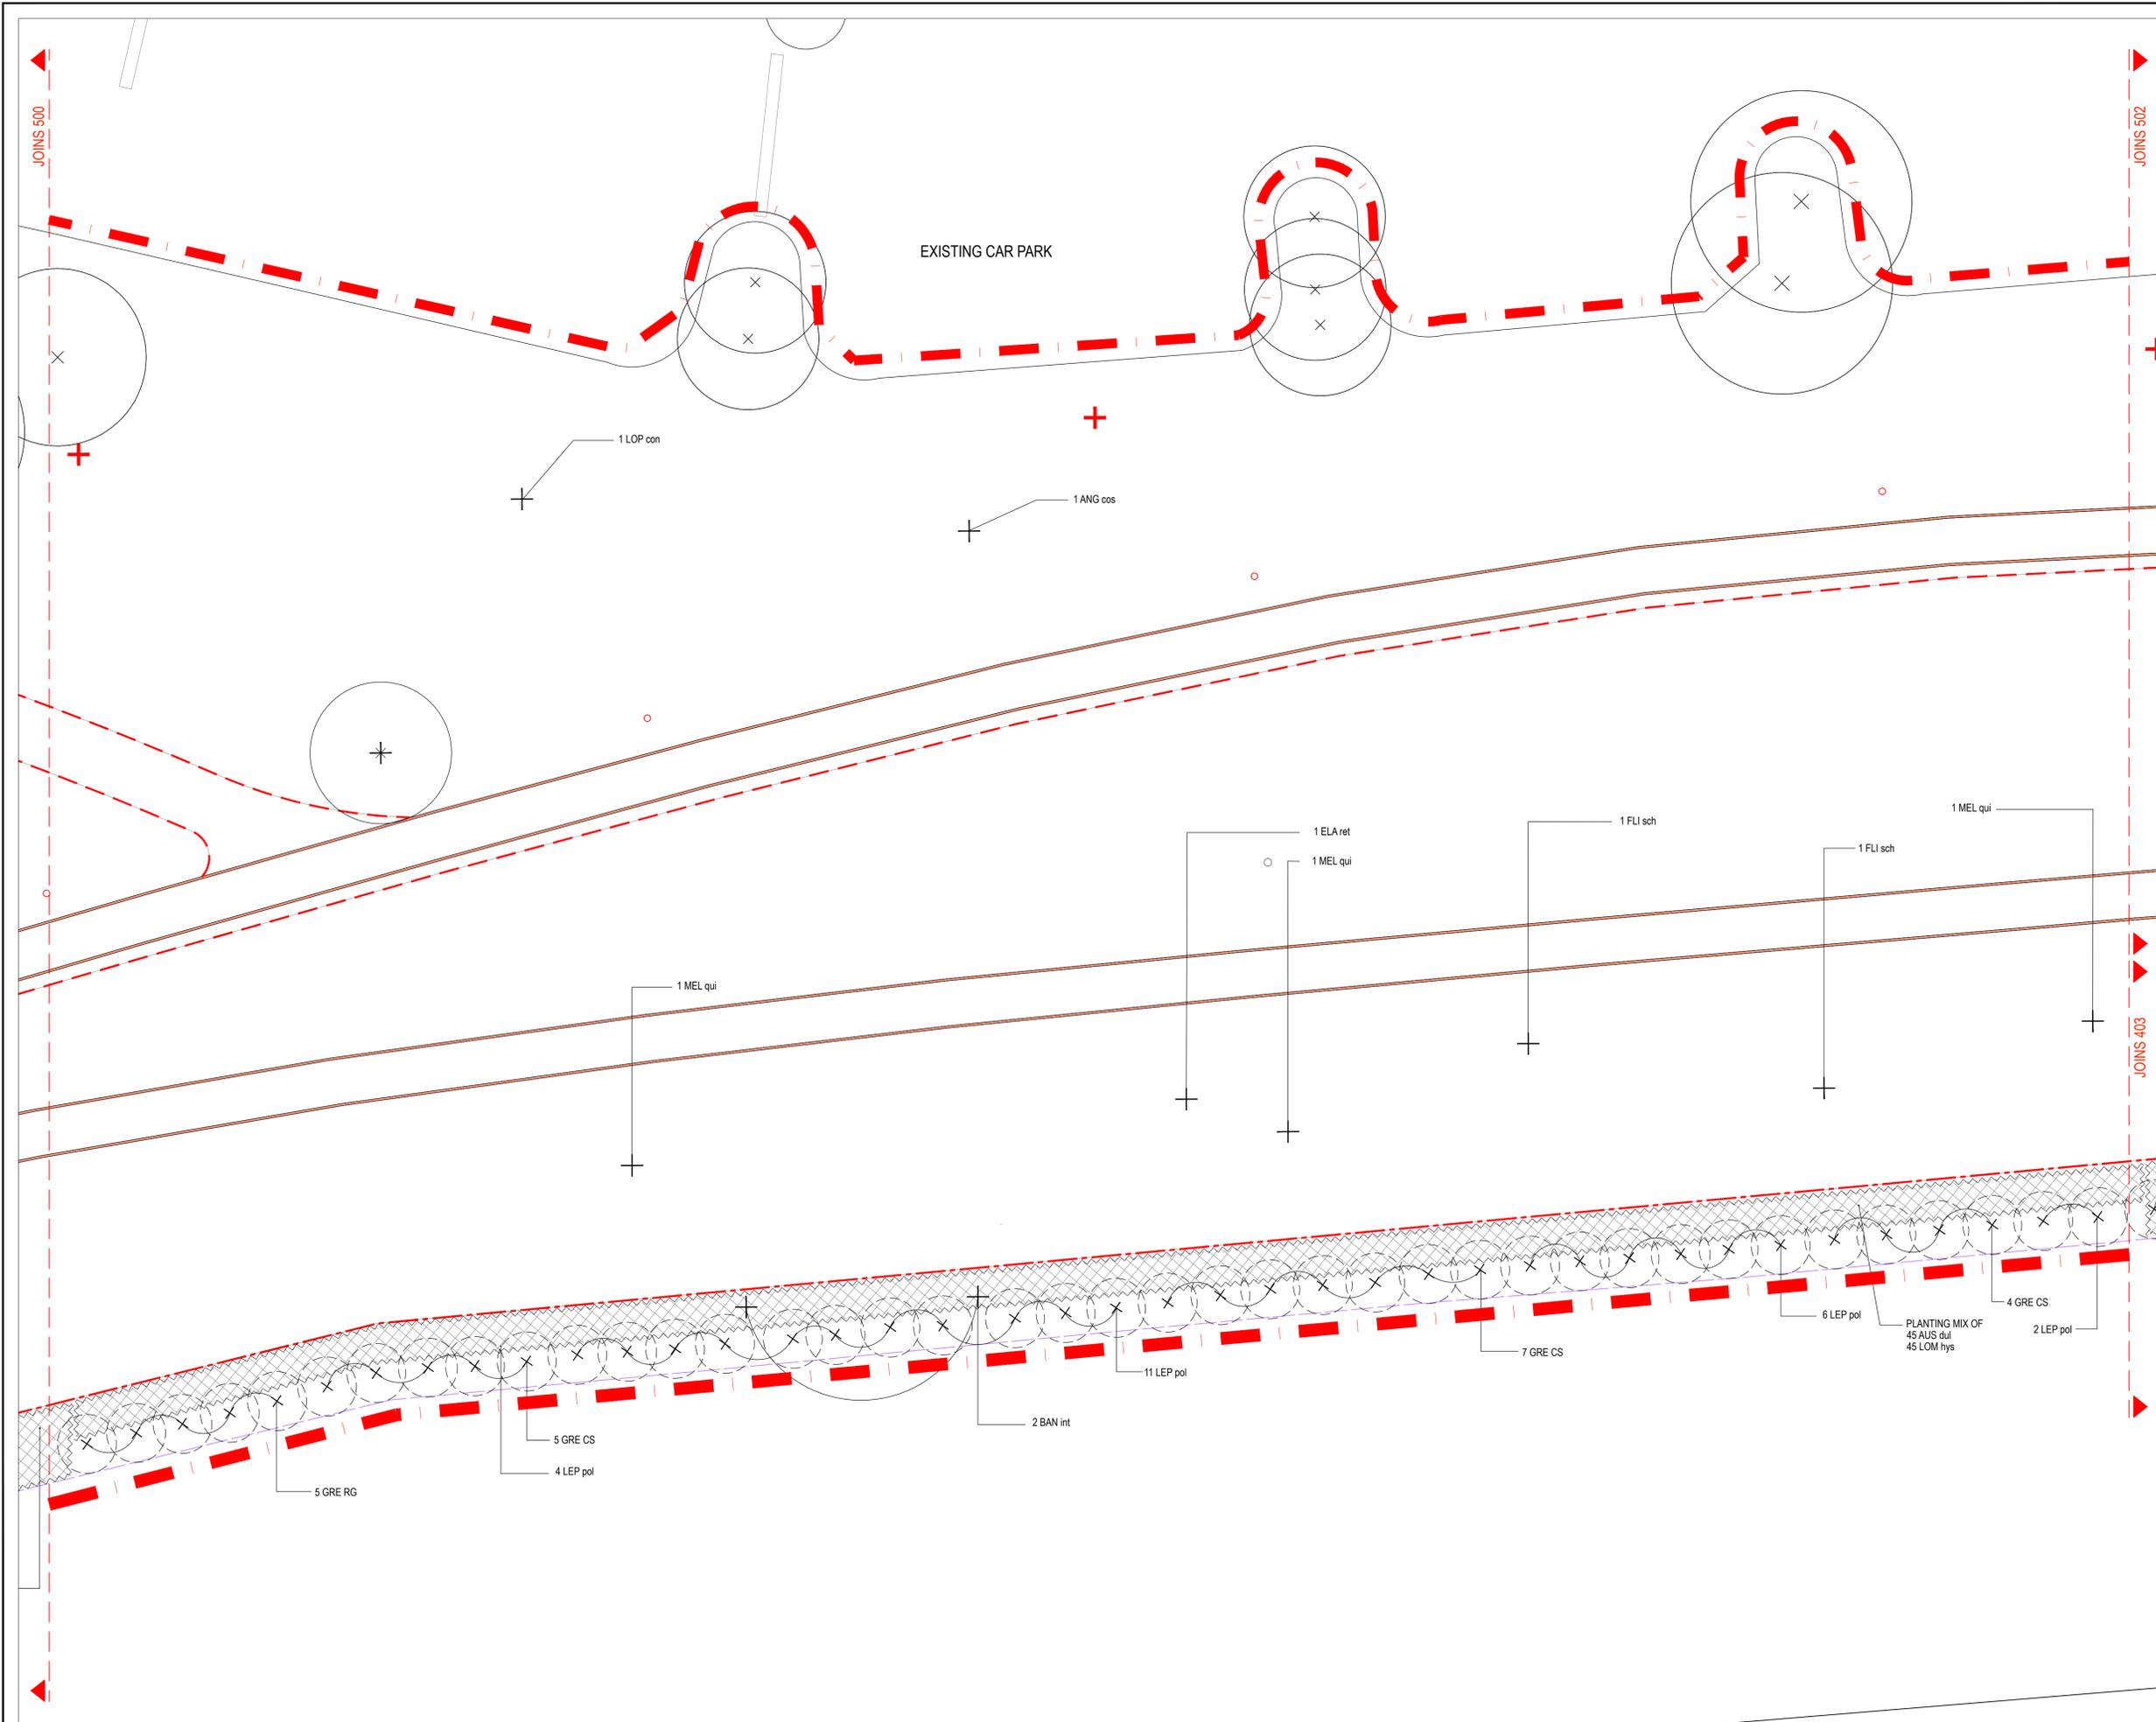

- KEY**
- EXISTING TREE TO BE RETAINED
 - TREE PLANTING
 - PALM PLANTING
 - SHRUBS AND FEATURE PLANTS- REFER TO PLANTING PLANS SCHEDULES.
 - SHRUBS AND FEATURE PLANTS- REFER TO PLANTING PLANS SCHEDULES.
 - HATCHED AND ZIG-ZAG BORDERED AREAS REPRESENT MASS PLANTING AREAS- REFER TO PLANTING PLANS AND PLANT SCHEDULES
 - ROOT BARRIER
 - CONCRETE WALL
 - EXTENT OF WORKS

NOTES

- ENSURE ALL SERVICES ARE LOCATED PRIOR TO COMMENCING LANDSCAPE WORKS

NOTE- THESE WORKS ARE IN A HERITAGE LISTED SITE. EXISTING ARTEFACTS ARE TO BE RETAINED UNLESS EXPLICITLY NOTED OTHERWISE. SEEK APPROVAL PRIOR TO THE DISTURBANCE OF ANY RAIL INFRASTRUCTURE

Revision	Description	Date	Initial
B	FOR TENDER	31.07.20	
A	DRAFT - FOR REVIEW	19.06.20	


1:100 @ A1

PLUMMER & SMITH
 landscape architecture / art / design
 abn: 17 634 944 737 m 0437 599 011
 po box 204 e dlan@plummerandsmith.com.au
 murwillumbah NSW 2484 w plummerandsmith.com.au
 © Copyright

BYRON SHIRE COUNCIL
RAIL CORRIDOR PARK

SOFTWORKS PLANS (SHEET 02 OF 07)

Designed DP Drawn IW
 Checked DP Approved [signature]
 Date 19.06.2020 Scale 1:100
 Job No. 211 Drawing No. 501 Revision B

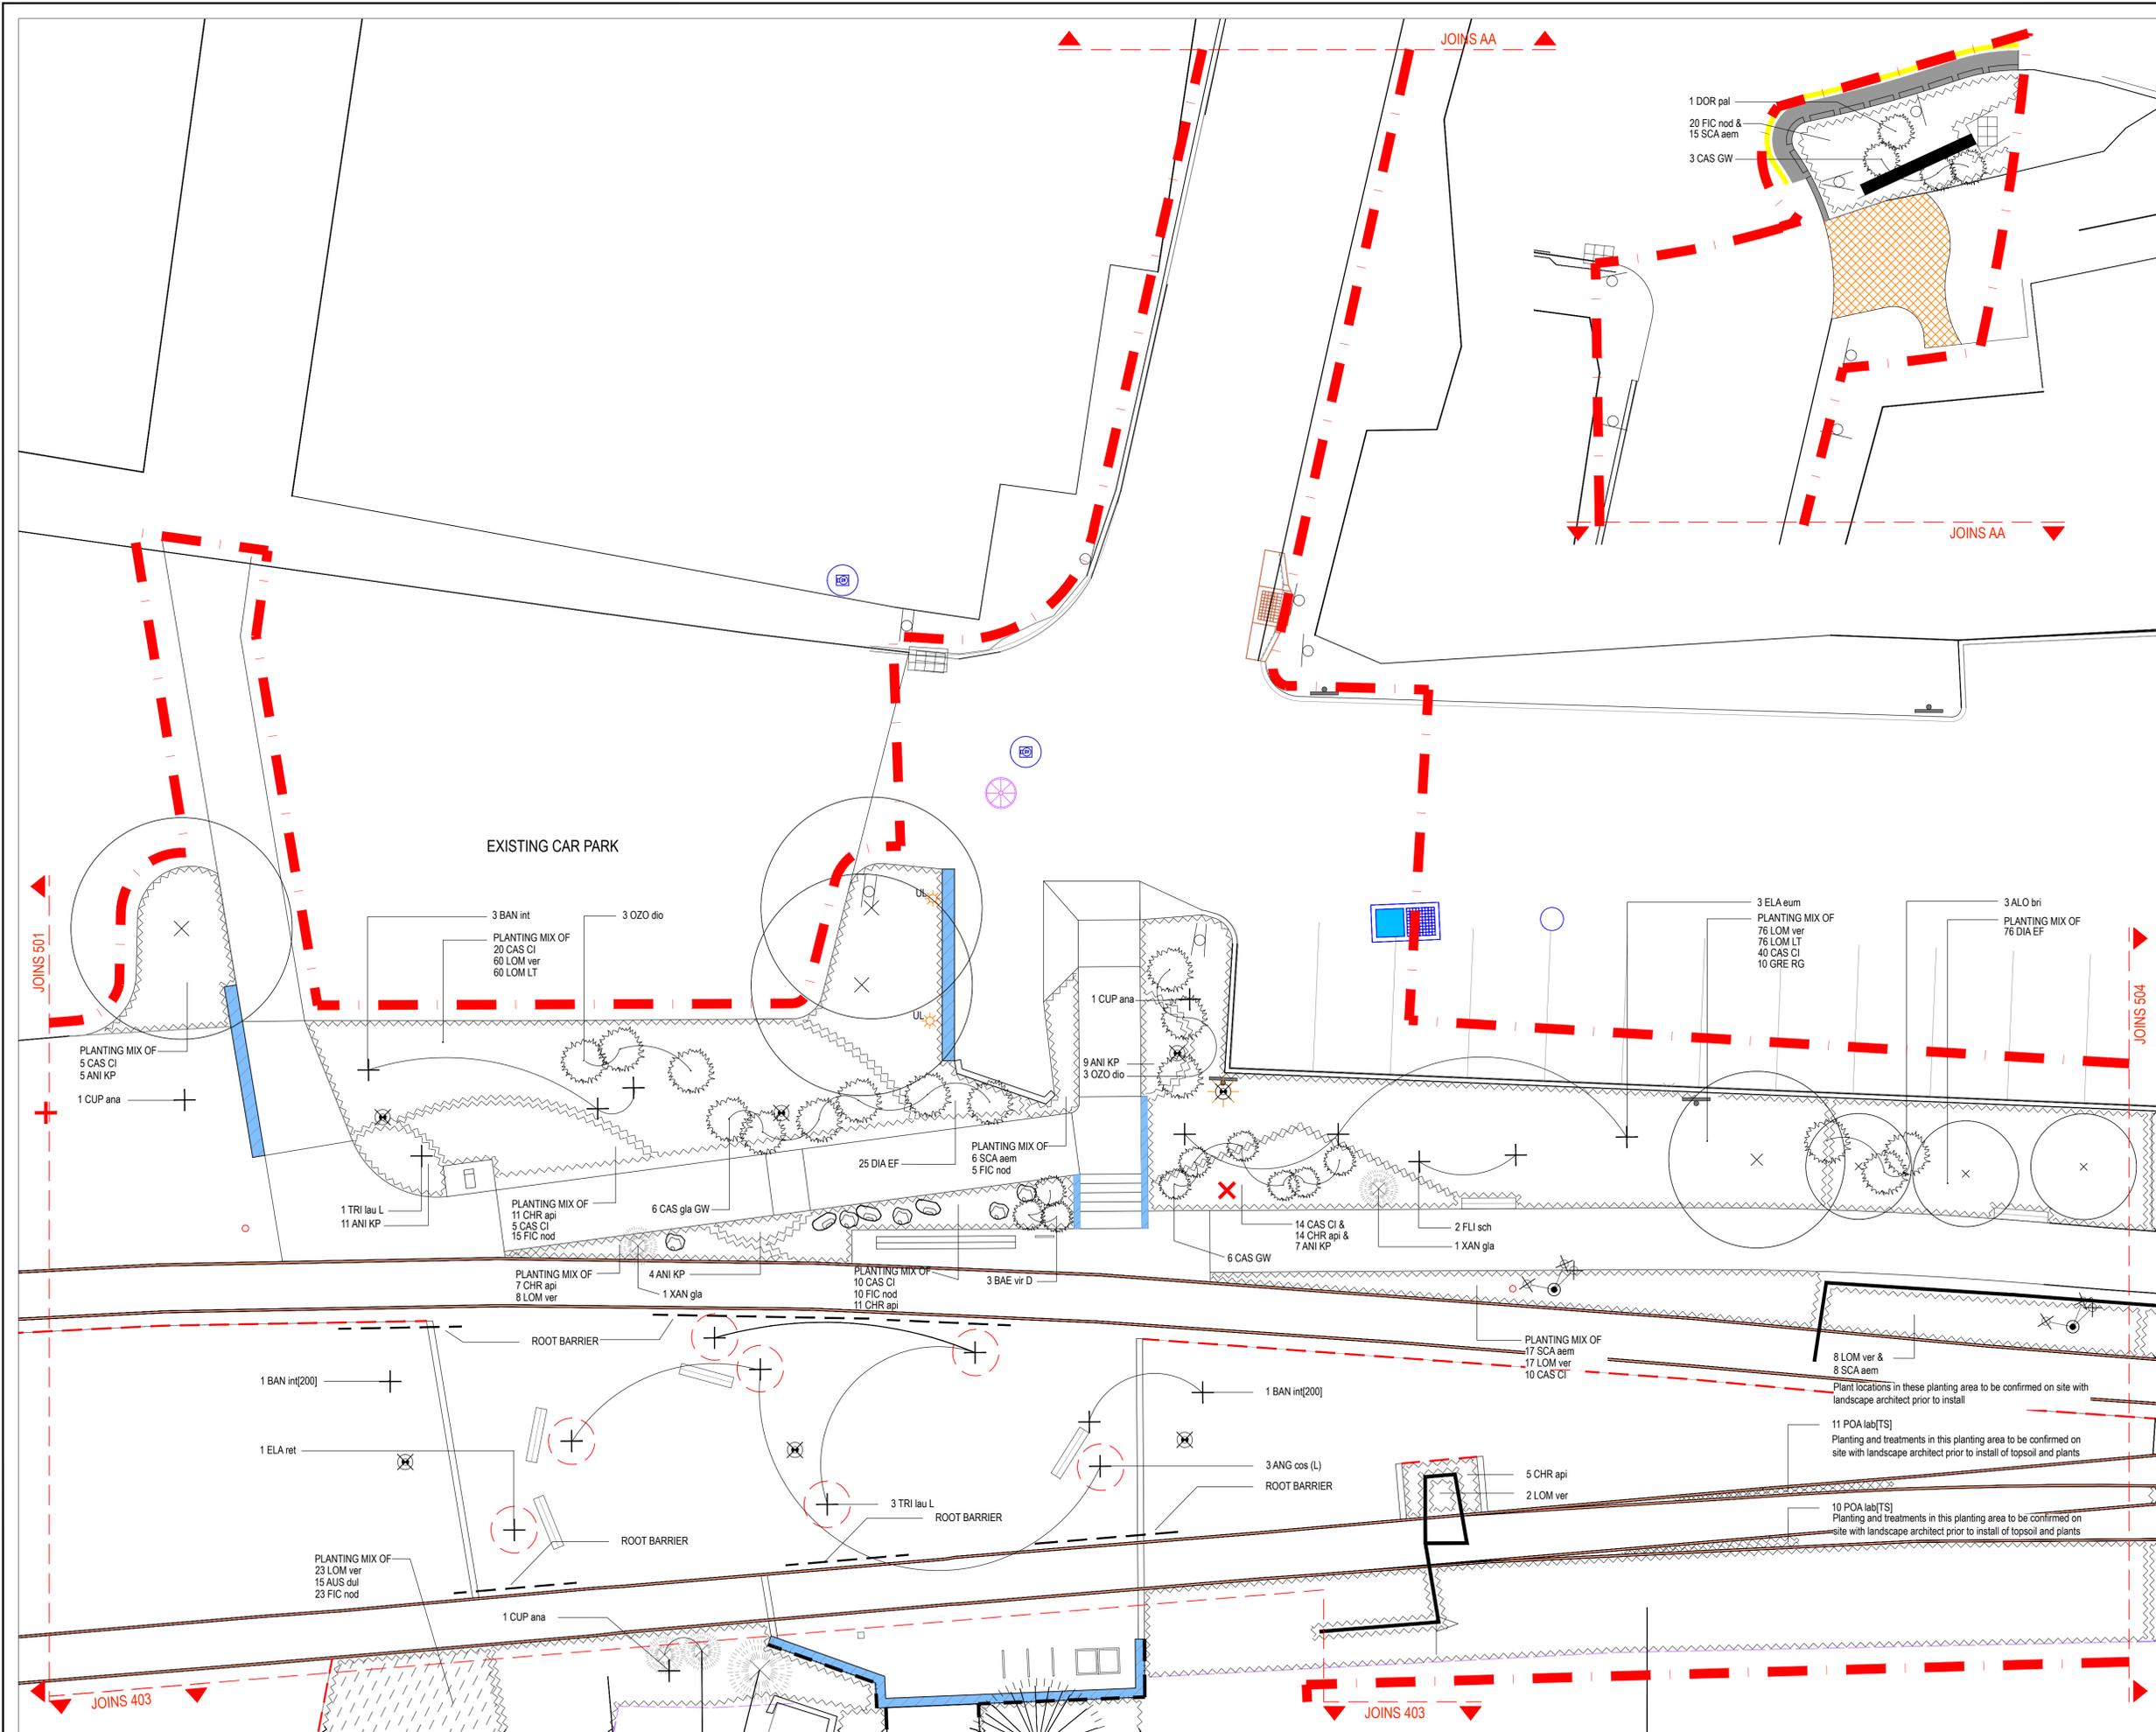

- KEY**
- EXISTING TREE TO BE RETAINED
 - TREE PLANTING
 - PALM PLANTING
 - SHRUBS AND FEATURE PLANTS- REFER TO PLANTING PLANS SCHEDULES.
 - SHRUBS AND FEATURE PLANTS- REFER TO PLANTING PLANS SCHEDULES.
 - HATCHED AND ZIG-ZAG BORDERED AREAS REPRESENT MASS PLANTING AREAS- REFER TO PLANTING PLANS AND PLANT SCHEDULES
 - ROOT BARRIER
 - CONCRETE WALL
 - EXTENT OF WORKS

NOTES

- ENSURE ALL SERVICES ARE LOCATED PRIOR TO COMMENCING LANDSCAPE WORKS

NOTE- THESE WORKS ARE IN A HERITAGE LISTED SITE. EXISTING ARTIFACTS ARE TO BE RETAINED UNLESS EXPLICITLY NOTED OTHERWISE. SEEK APPROVAL PRIOR TO THE DISTURBANCE OF ANY RAIL INFRASTRUCTURE

Revision	Description	Date	Initial
B	FOR TENDER	31.07.20	
A	DRAFT - FOR REVIEW	19.06.20	

1:100 @ A1


PLUMMER & SMITH
 landscape architecture / art / design
 abn: 17 534 944 737 m 0437 599 011
 po box 204 e dar@plummerandsmith.com.au
 murwillumbah NSW 2484 w plummerandsmith.com.au
 © Copyright

BYRON SHIRE COUNCIL

RAIL CORRIDOR PARK

SOFTWORKS PLANS (SHEET 03 OF 07)

Designed DP	Drawn IW	(please scanned signature here, preferably use a transparent .png image. Layer order: jpg images to back if you must use one)
Checked DP	Approved	
Date 19.06.2020	Scale 1:100	
Job No. 211	Drawing No. 502	Revision B

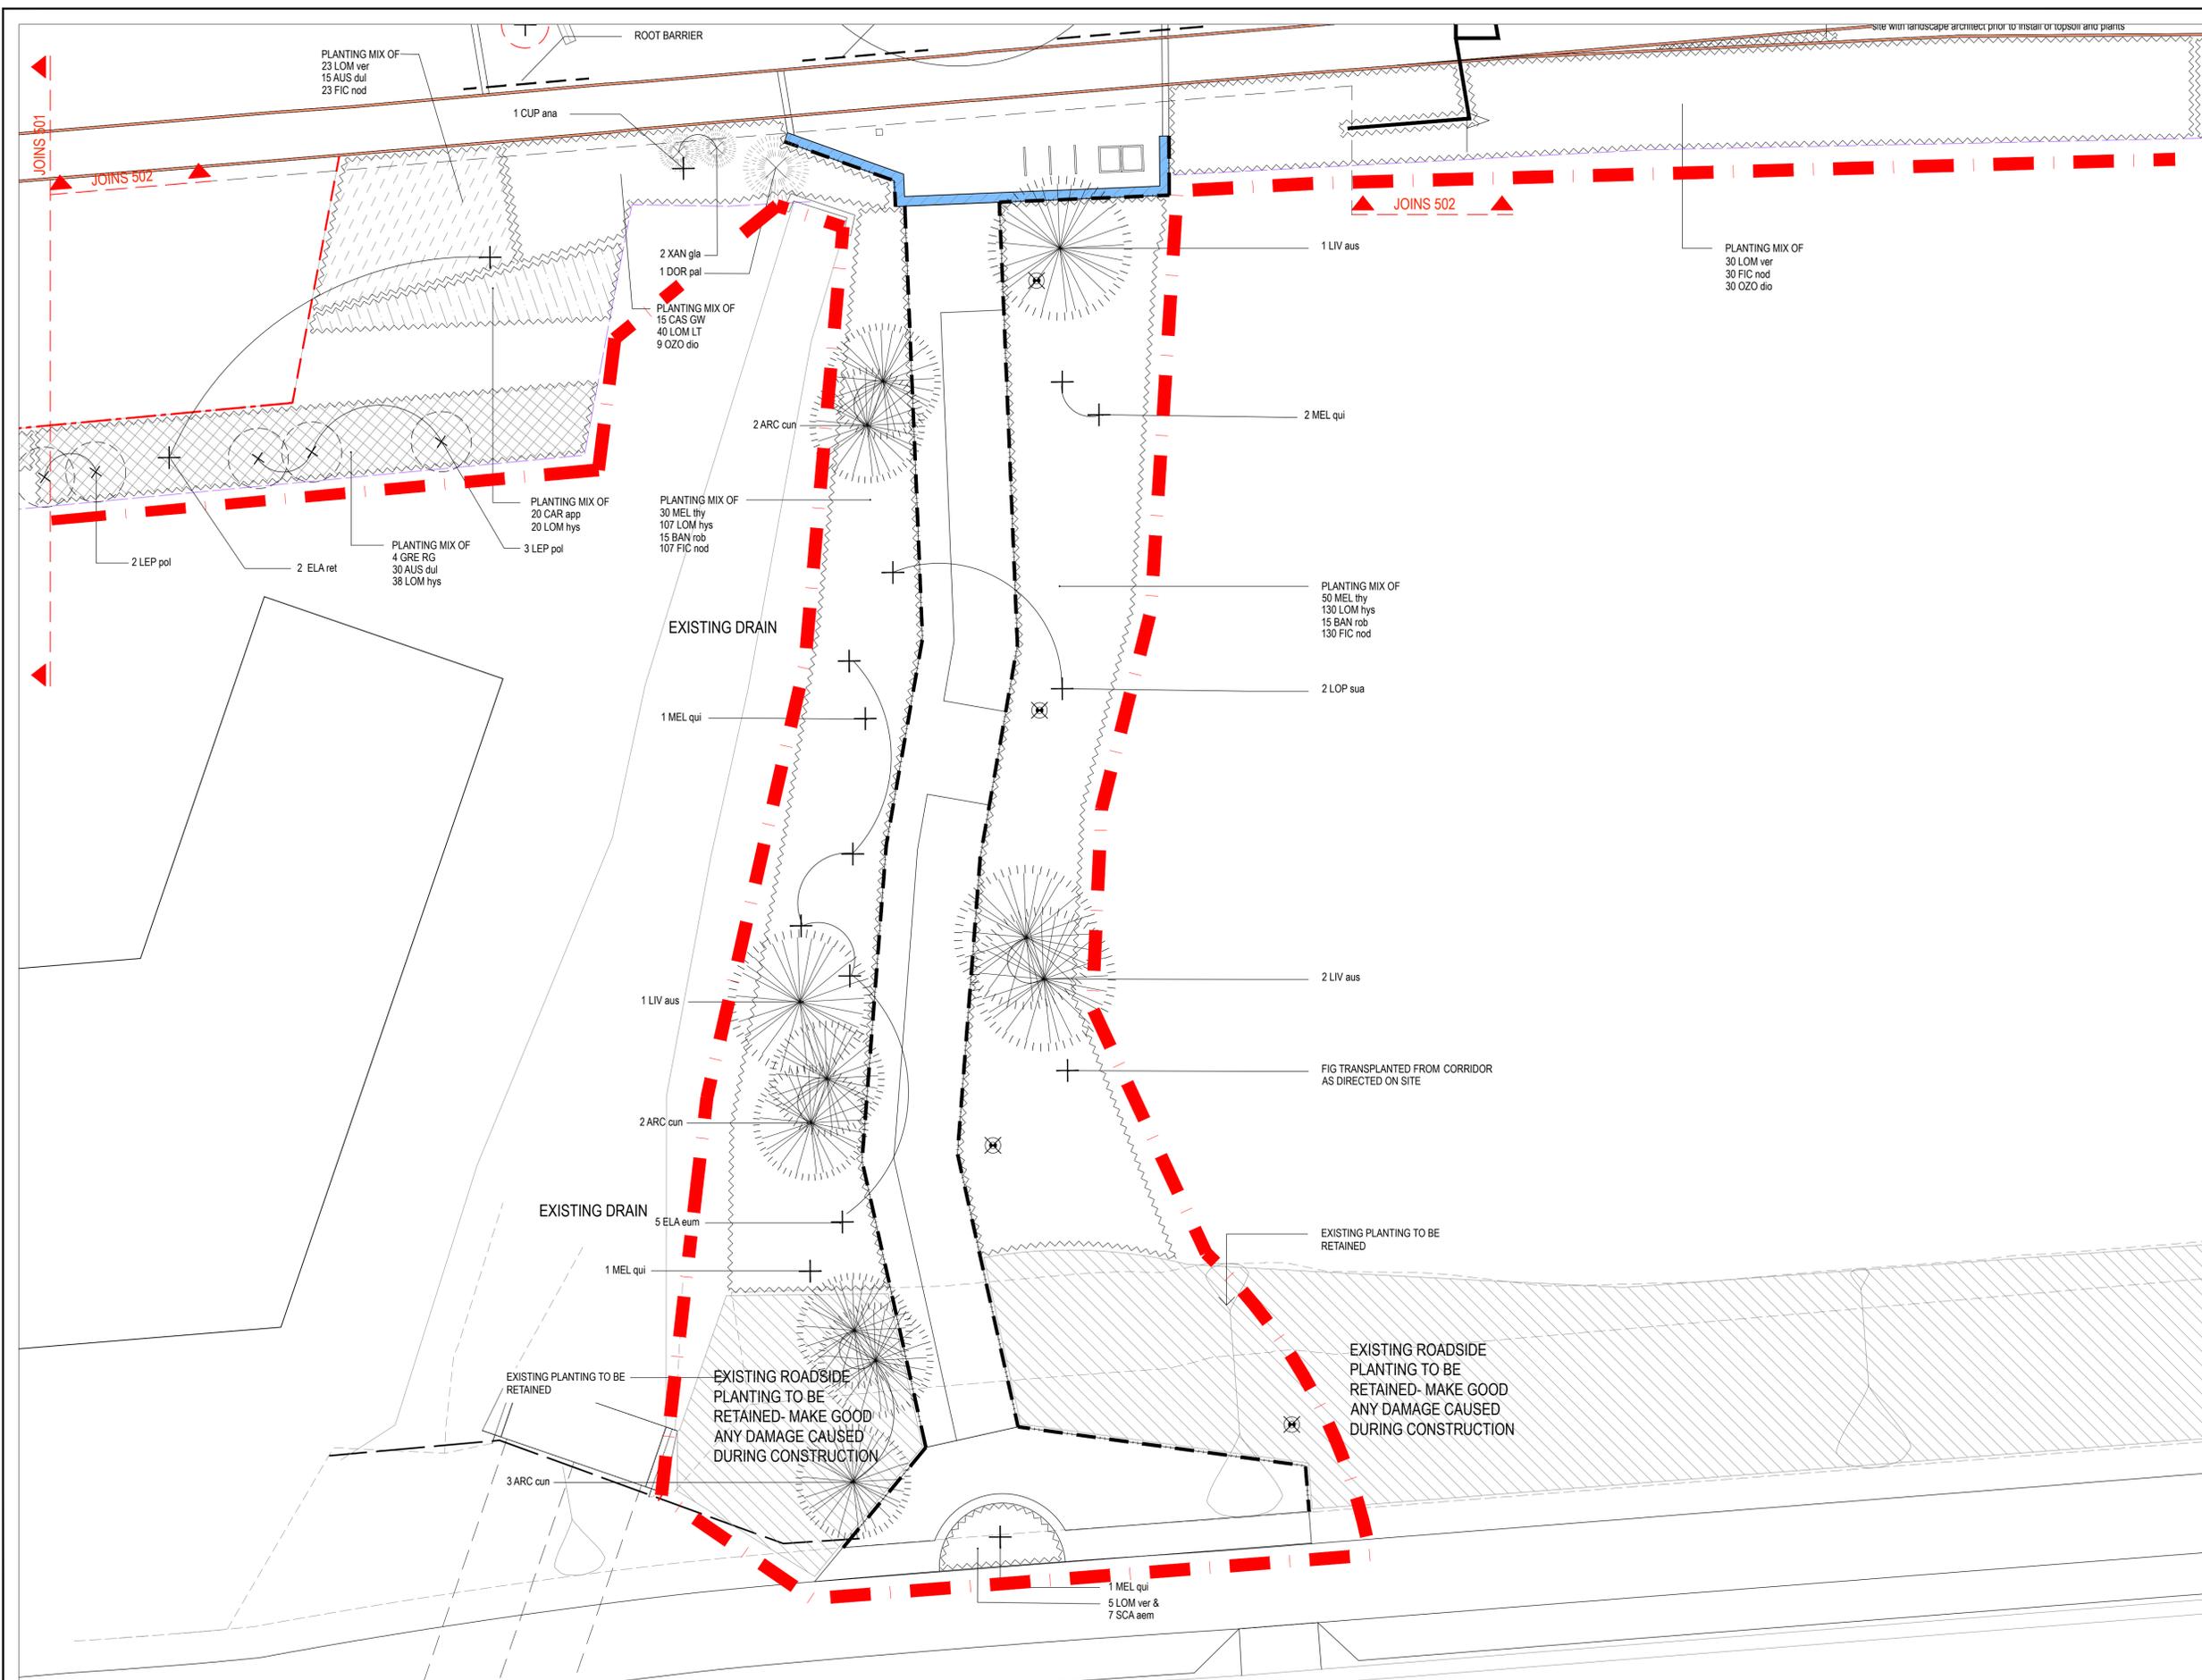

KEY

- EXISTING TREE TO BE RETAINED
- TREE PLANTING
- PALM PLANTING
- SHRUBS AND FEATURE PLANTS- REFER TO PLANTING PLANS SCHEDULES.
- SHRUBS AND FEATURE PLANTS- REFER TO PLANTING PLANS SCHEDULES.
- HATCHED AND ZIG-ZAG BORDERED AREAS REPRESENT MASS PLANTING AREAS- REFER TO PLANTING PLANS AND PLANT SCHEDULES
- ROOT BARRIER
- CONCRETE WALL
- EXTENT OF WORKS

NOTES

- ENSURE ALL SERVICES ARE LOCATED PRIOR TO COMMENCING LANDSCAPE WORKS

NOTE- THESE WORKS ARE IN A HERITAGE LISTED SITE. EXISTING ARTEFACTS ARE TO BE RETAINED UNLESS EXPLICITLY NOTED OTHERWISE. SEEK APPROVAL PRIOR TO THE DISTURBANCE OF ANY RAIL INFRASTRUCTURE

Revision	Description	Date	Initial
B	FOR TENDER	31.07.20	
A	DRAFT - FOR REVIEW	19.06.20	

1:100 @ A1


PLUMMER & SMITH
 landscape architecture / art / design
 abn: 17 634 944 737 m 0437 599 011
 po box 204 e dar@plummerandsmith.com.au
 murrumbidgee NSW 2484 w plummerandsmith.com.au
 © Copyright

BYRON SHIRE COUNCIL

RAIL CORRIDOR PARK

SOFTWORKS PLANS (SHEET 04 OF 07)

Designed DP Drawn IW
 Checked DP Approved [signature]
 Date 19.06.2020 Scale 1:100
 Job No. 211 Drawing No. 503 Revision B

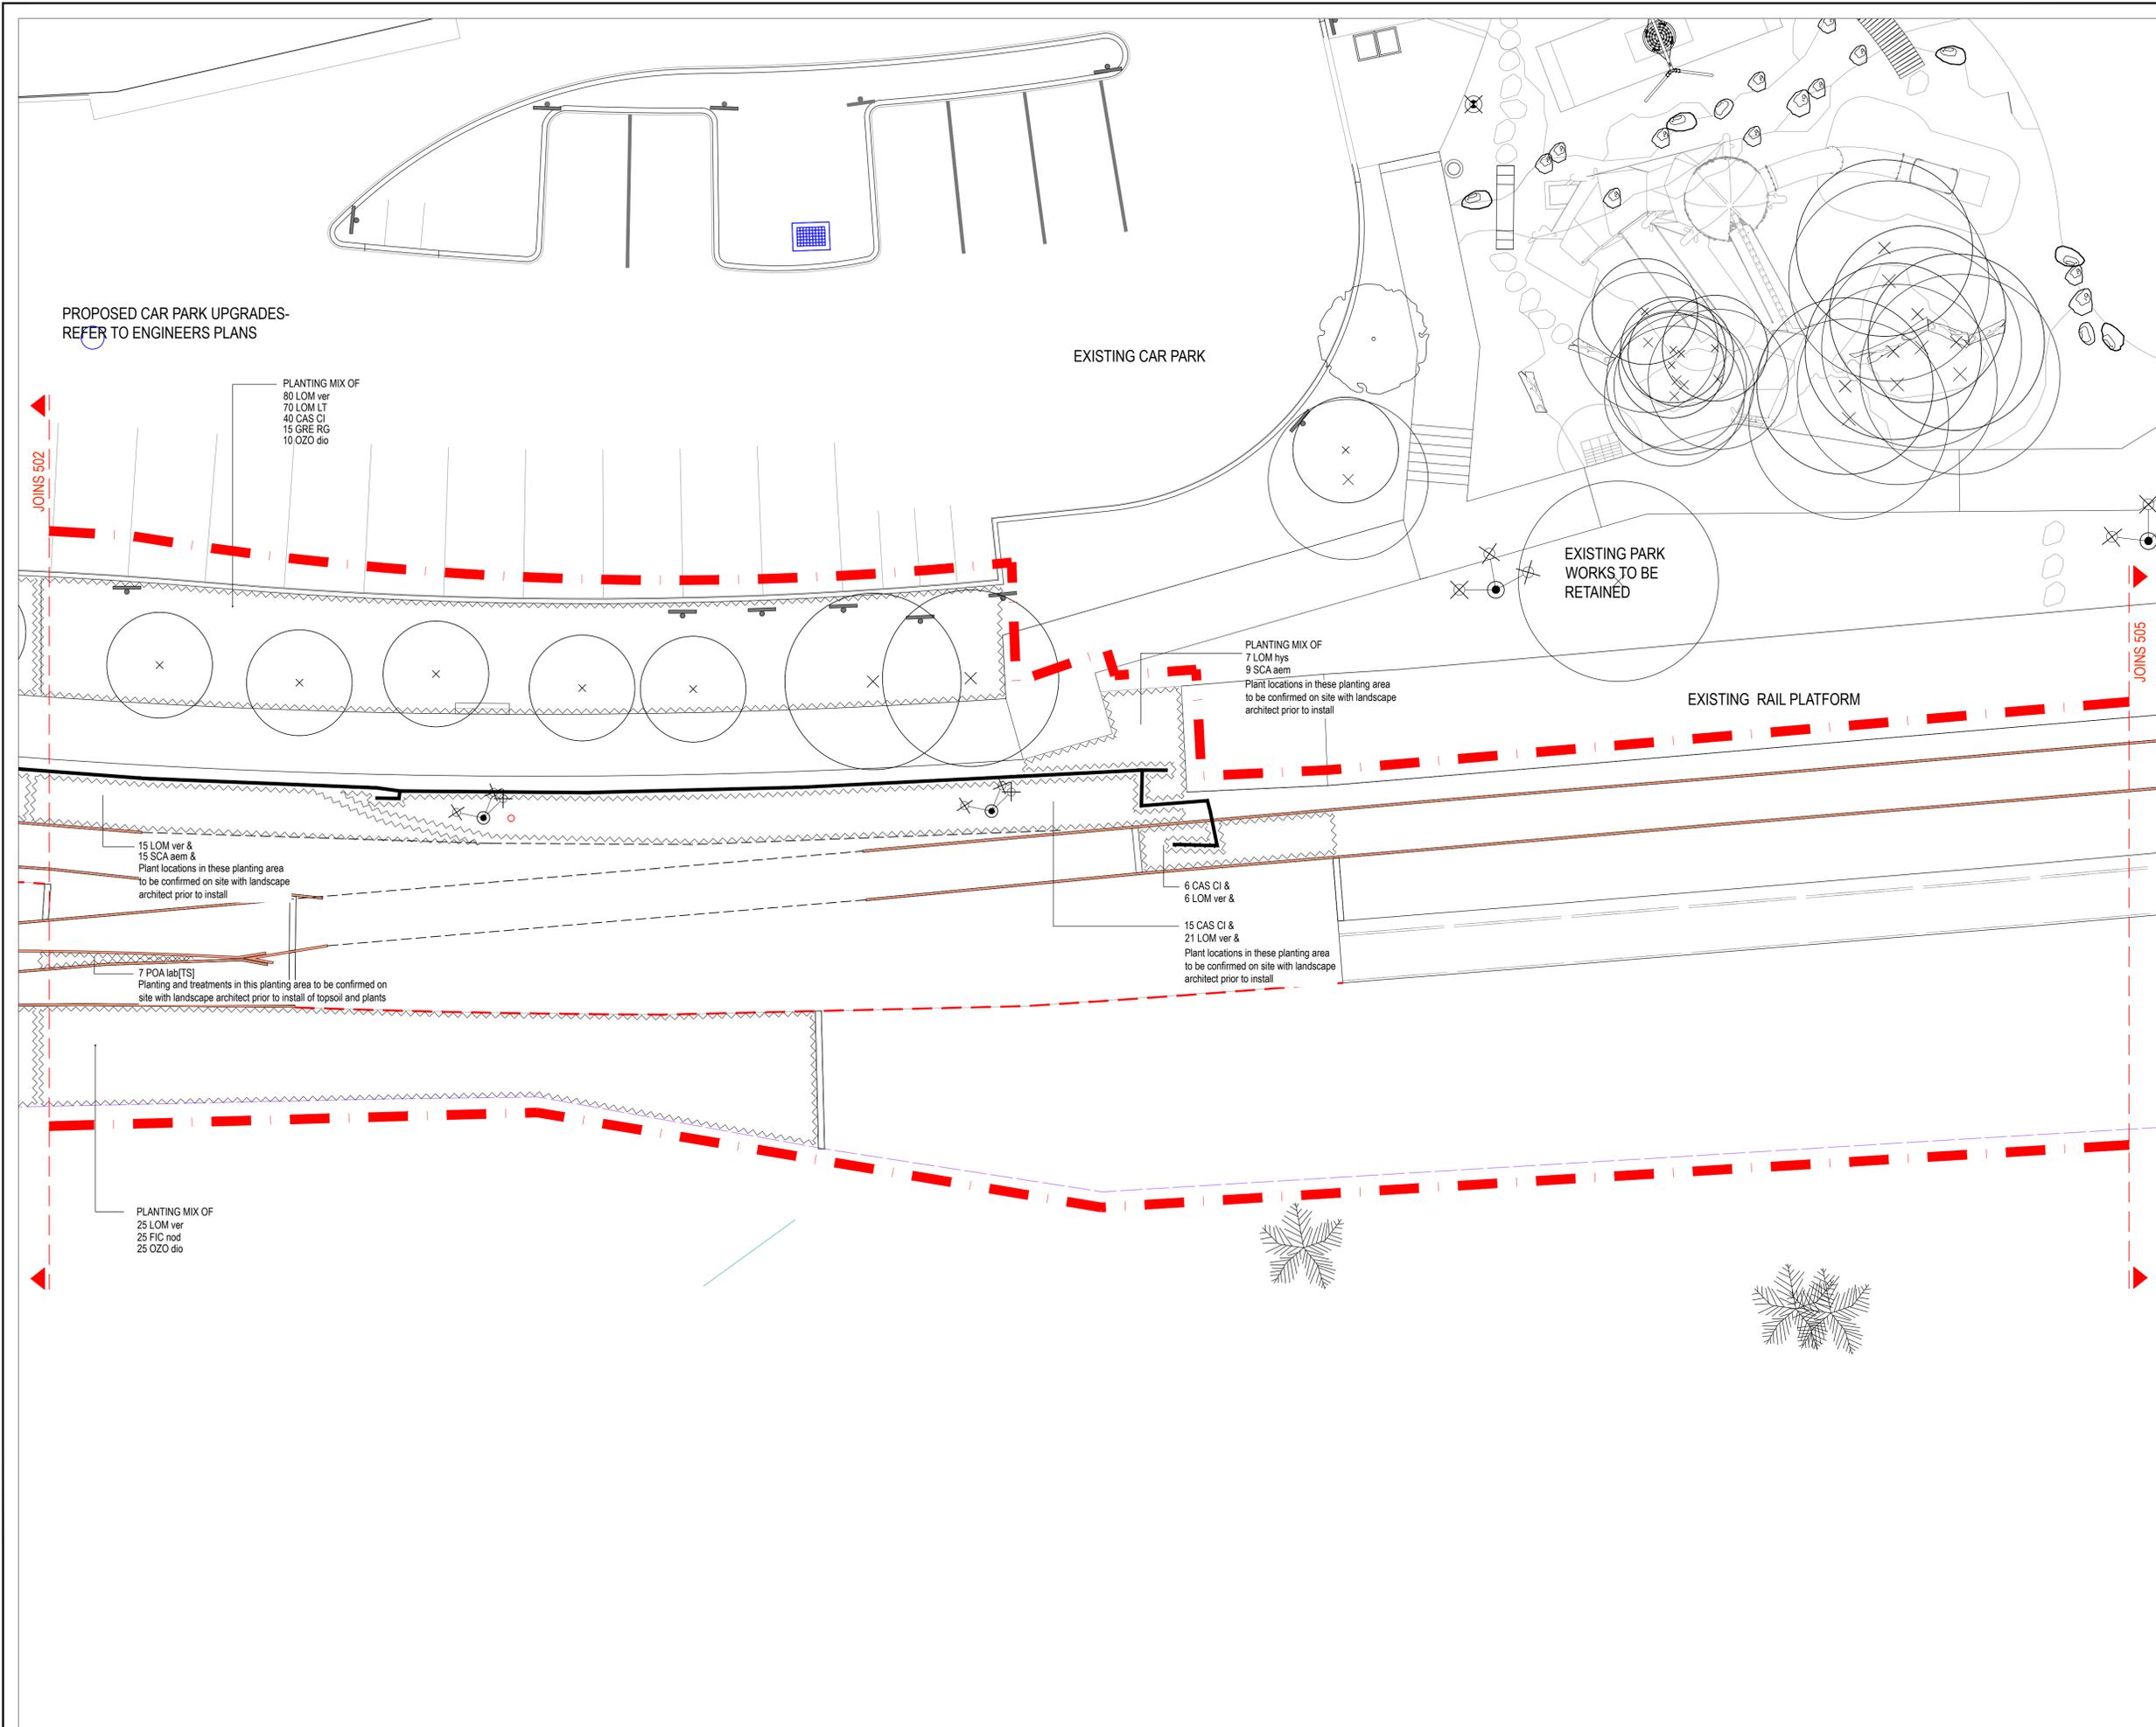

- KEY**
- EXISTING TREE TO BE RETAINED
 - TREE PLANTING
 - PALM PLANTING
 - SHRUBS AND FEATURE PLANTS- REFER TO PLANTING PLANS SCHEDULES.
 - HATCHED AND ZIG-ZAG BORDERED AREAS REPRESENT MASS PLANTING AREAS- REFER TO PLANTING PLANS AND PLANT SCHEDULES
 - ROOT BARRIER
 - CONCRETE WALL
 - EXTENT OF WORKS

NOTES

- ENSURE ALL SERVICES ARE LOCATED PRIOR TO COMMENCING LANDSCAPE WORKS

NOTE- THESE WORKS ARE IN A HERITAGE LISTED SITE. EXISTING ARTEFACTS ARE TO BE RETAINED UNLESS EXPLICITLY NOTED OTHERWISE. SEEK APPROVAL PRIOR TO THE DISTURBANCE OF ANY RAIL INFRASTRUCTURE

Revision	Description	Date	Initial
B	FOR TENDER	31.07.20	
A	DRAFT - FOR REVIEW	19.06.20	

1:100 @ A1


PLUMMER & SMITH
 landscape architecture / art / design
 abn: 17 634 944 737 m 0437 599 011
 po box 204 e dlan@plummerandsmith.com.au
 murrumbidgee NSW 2484 w plummerandsmith.com.au
 © Copyright

BYRON SHIRE COUNCIL

RAIL CORRIDOR PARK

SOFTWORKS PLANS (SHEET 05 OF 07)

Designed DP Drawn IW
 Checked DP Approved [signature]
 Date 19.06.2020 Scale 1:100
 Job No. 211 Drawing No. 504 Revision B

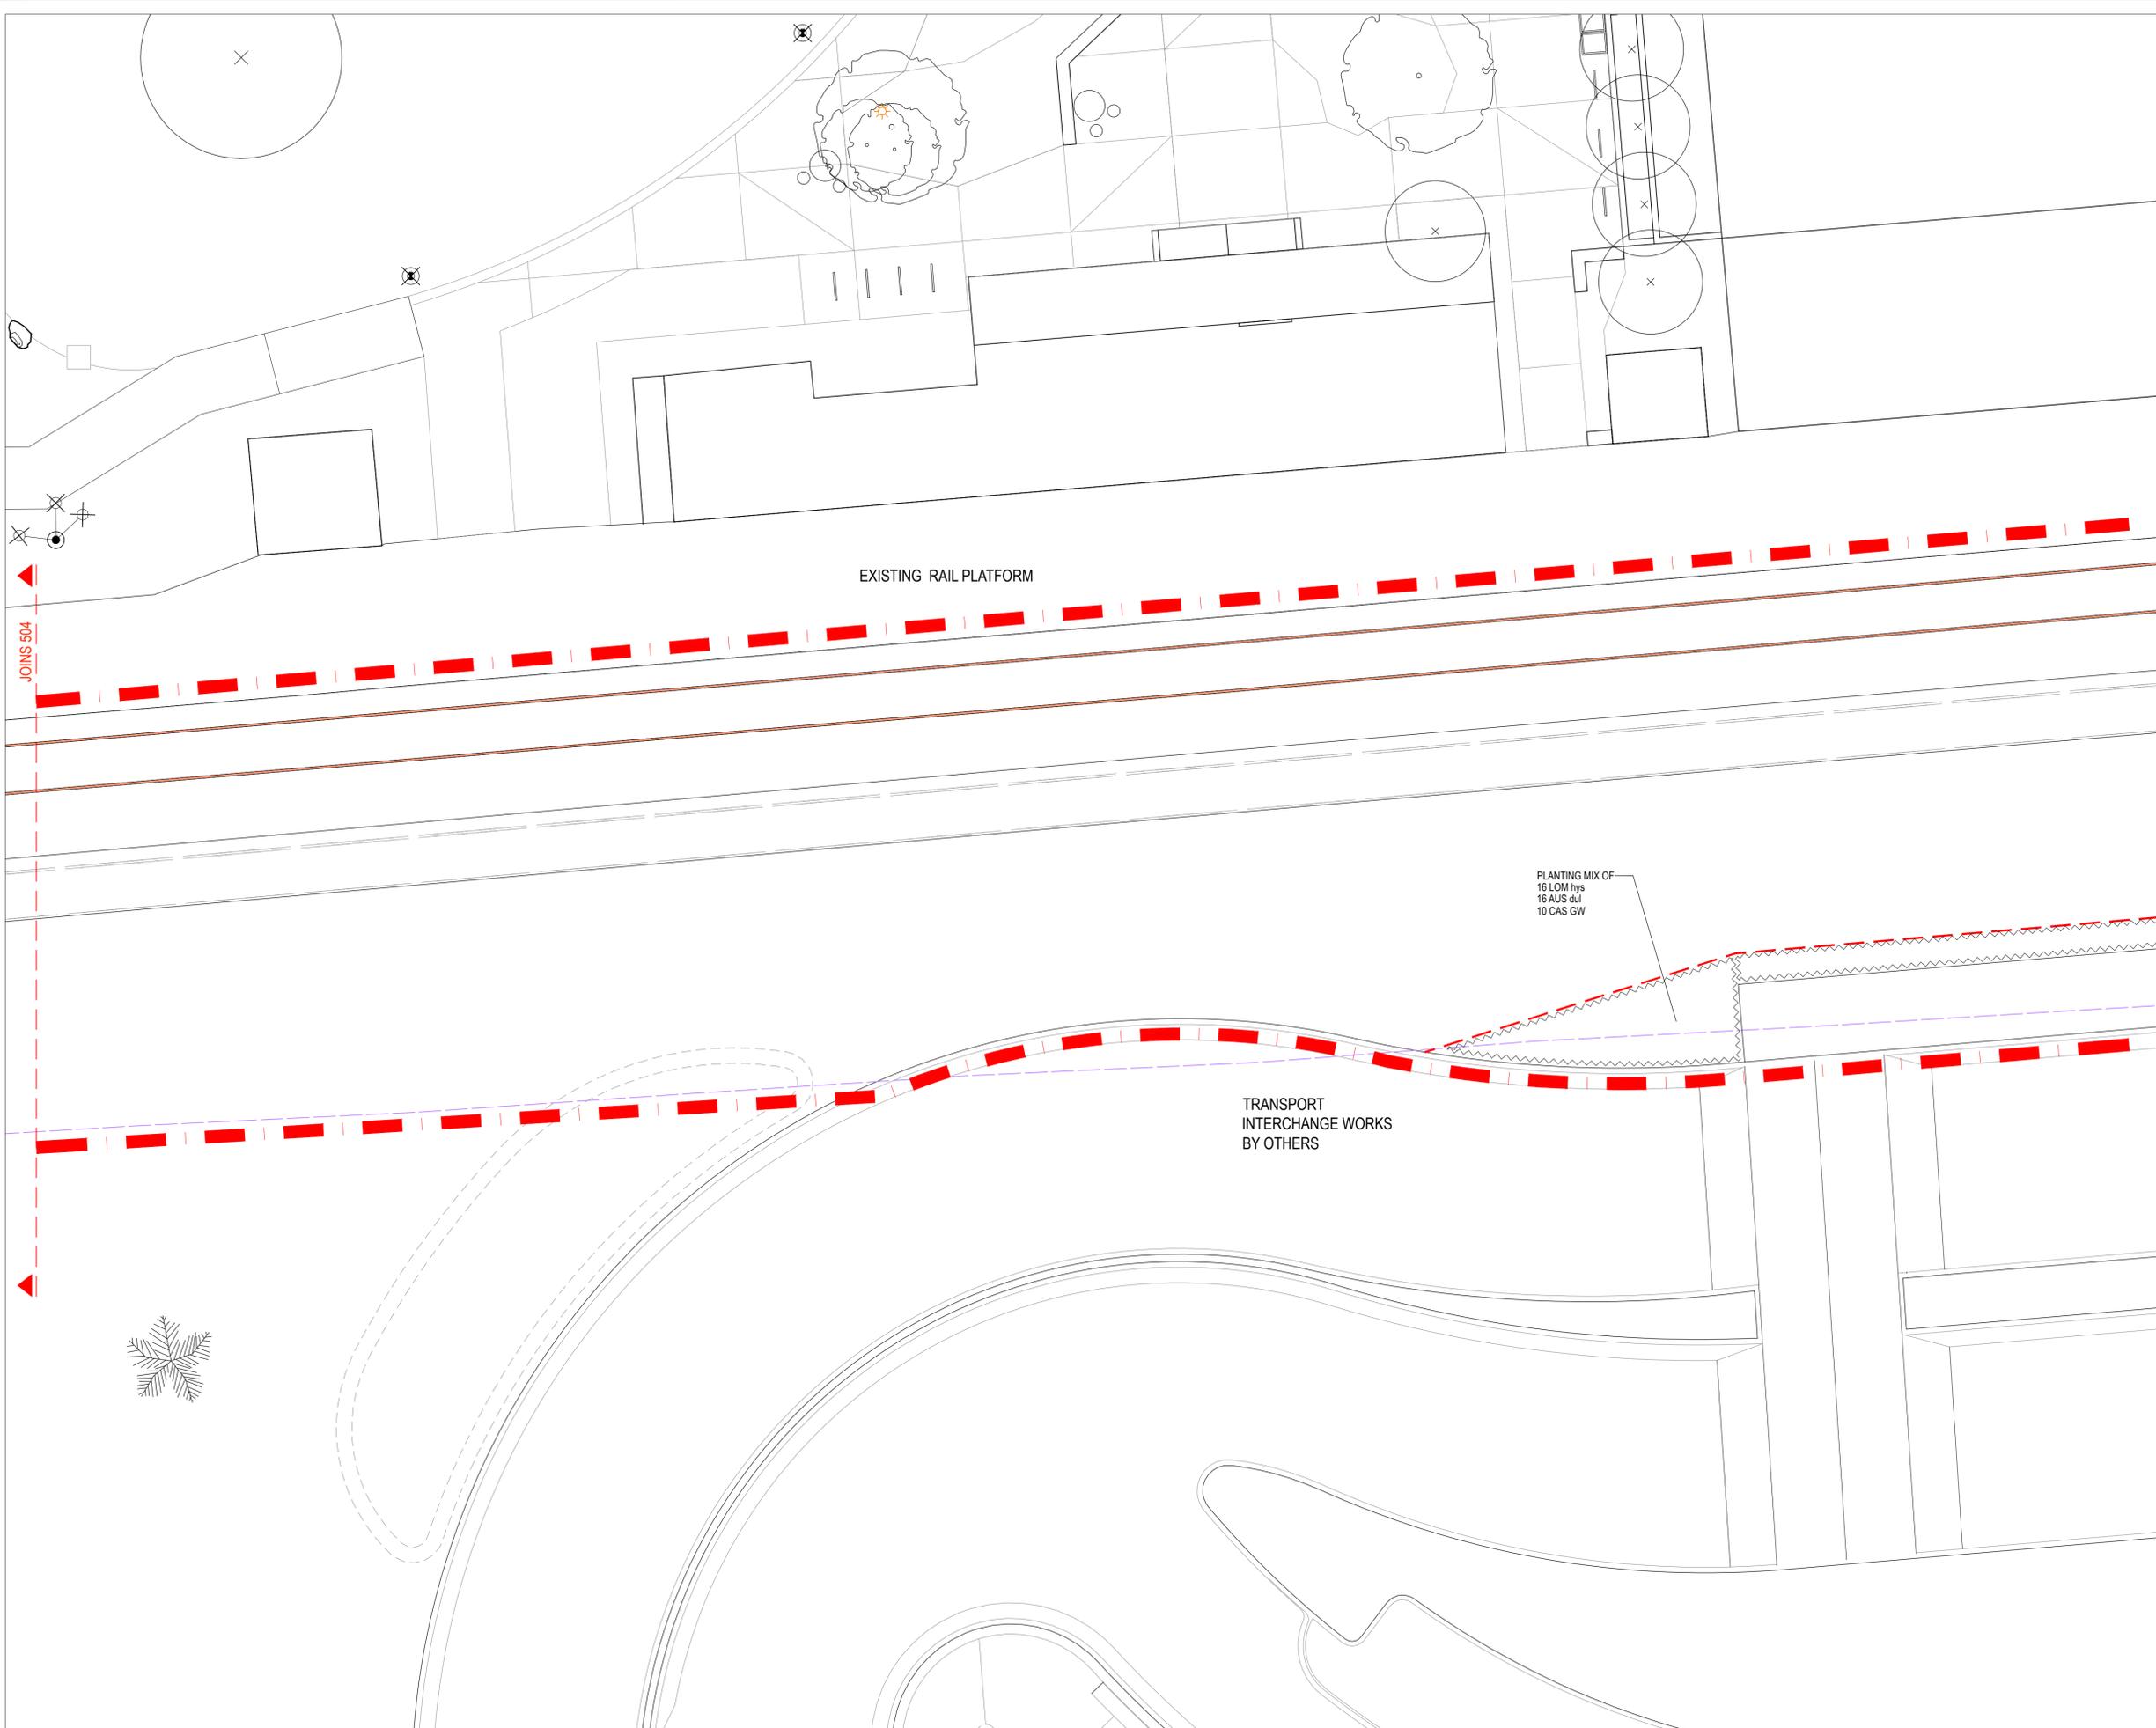

- KEY**
- EXISTING TREE TO BE RETAINED
 - TREE PLANTING
 - PALM PLANTING
 - SHRUBS AND FEATURE PLANTS- REFER TO PLANTING PLANS SCHEDULES.
 - SHRUBS AND FEATURE PLANTS- REFER TO PLANTING PLANS SCHEDULES.
 - SHRUBS AND FEATURE PLANTS- REFER TO PLANTING PLANS SCHEDULES.
 - HATCHED AND ZIG-ZAG BORDERED AREAS REPRESENT MASS PLANTING AREAS- REFER TO PLANTING PLANS AND PLANT SCHEDULES
 - ROOT BARRIER
 - CONCRETE WALL
 - EXTENT OF WORKS

- NOTES**
1. ENSURE ALL SERVICES ARE LOCATED PRIOR TO COMMENCING LANDSCAPE WORKS

NOTE- THESE WORKS ARE IN A HERITAGE LISTED SITE. EXISTING ARTEFACTS ARE TO BE RETAINED UNLESS EXPLICITLY NOTED OTHERWISE. SEEK APPROVAL PRIOR TO THE DISTURBANCE OF ANY RAIL INFRASTRUCTURE

Revision	Description	Date	Initial
B	FOR TENDER	31.07.20	
A	DRAFT - FOR REVIEW	19.06.20	

1:100 @ A1


PLUMMER & SMITH
 landscape architecture / art / design
 abn: 17 634 944 737 m 0437 599 011
 po box 204 e dlan@plummerandsmith.com.au
 murrumbidgee NSW 2484 w plummerandsmith.com.au
 © Copyright

BYRON SHIRE COUNCIL

RAIL CORRIDOR PARK

SOFTWORKS PLANS (SHEET 06 OF 07)

Designed DP Drawn IW
 Checked DP Approved [signature]
 Date 19.06.2020 Scale 1:100
 Job No. 211 Drawing No. 505 Revision B

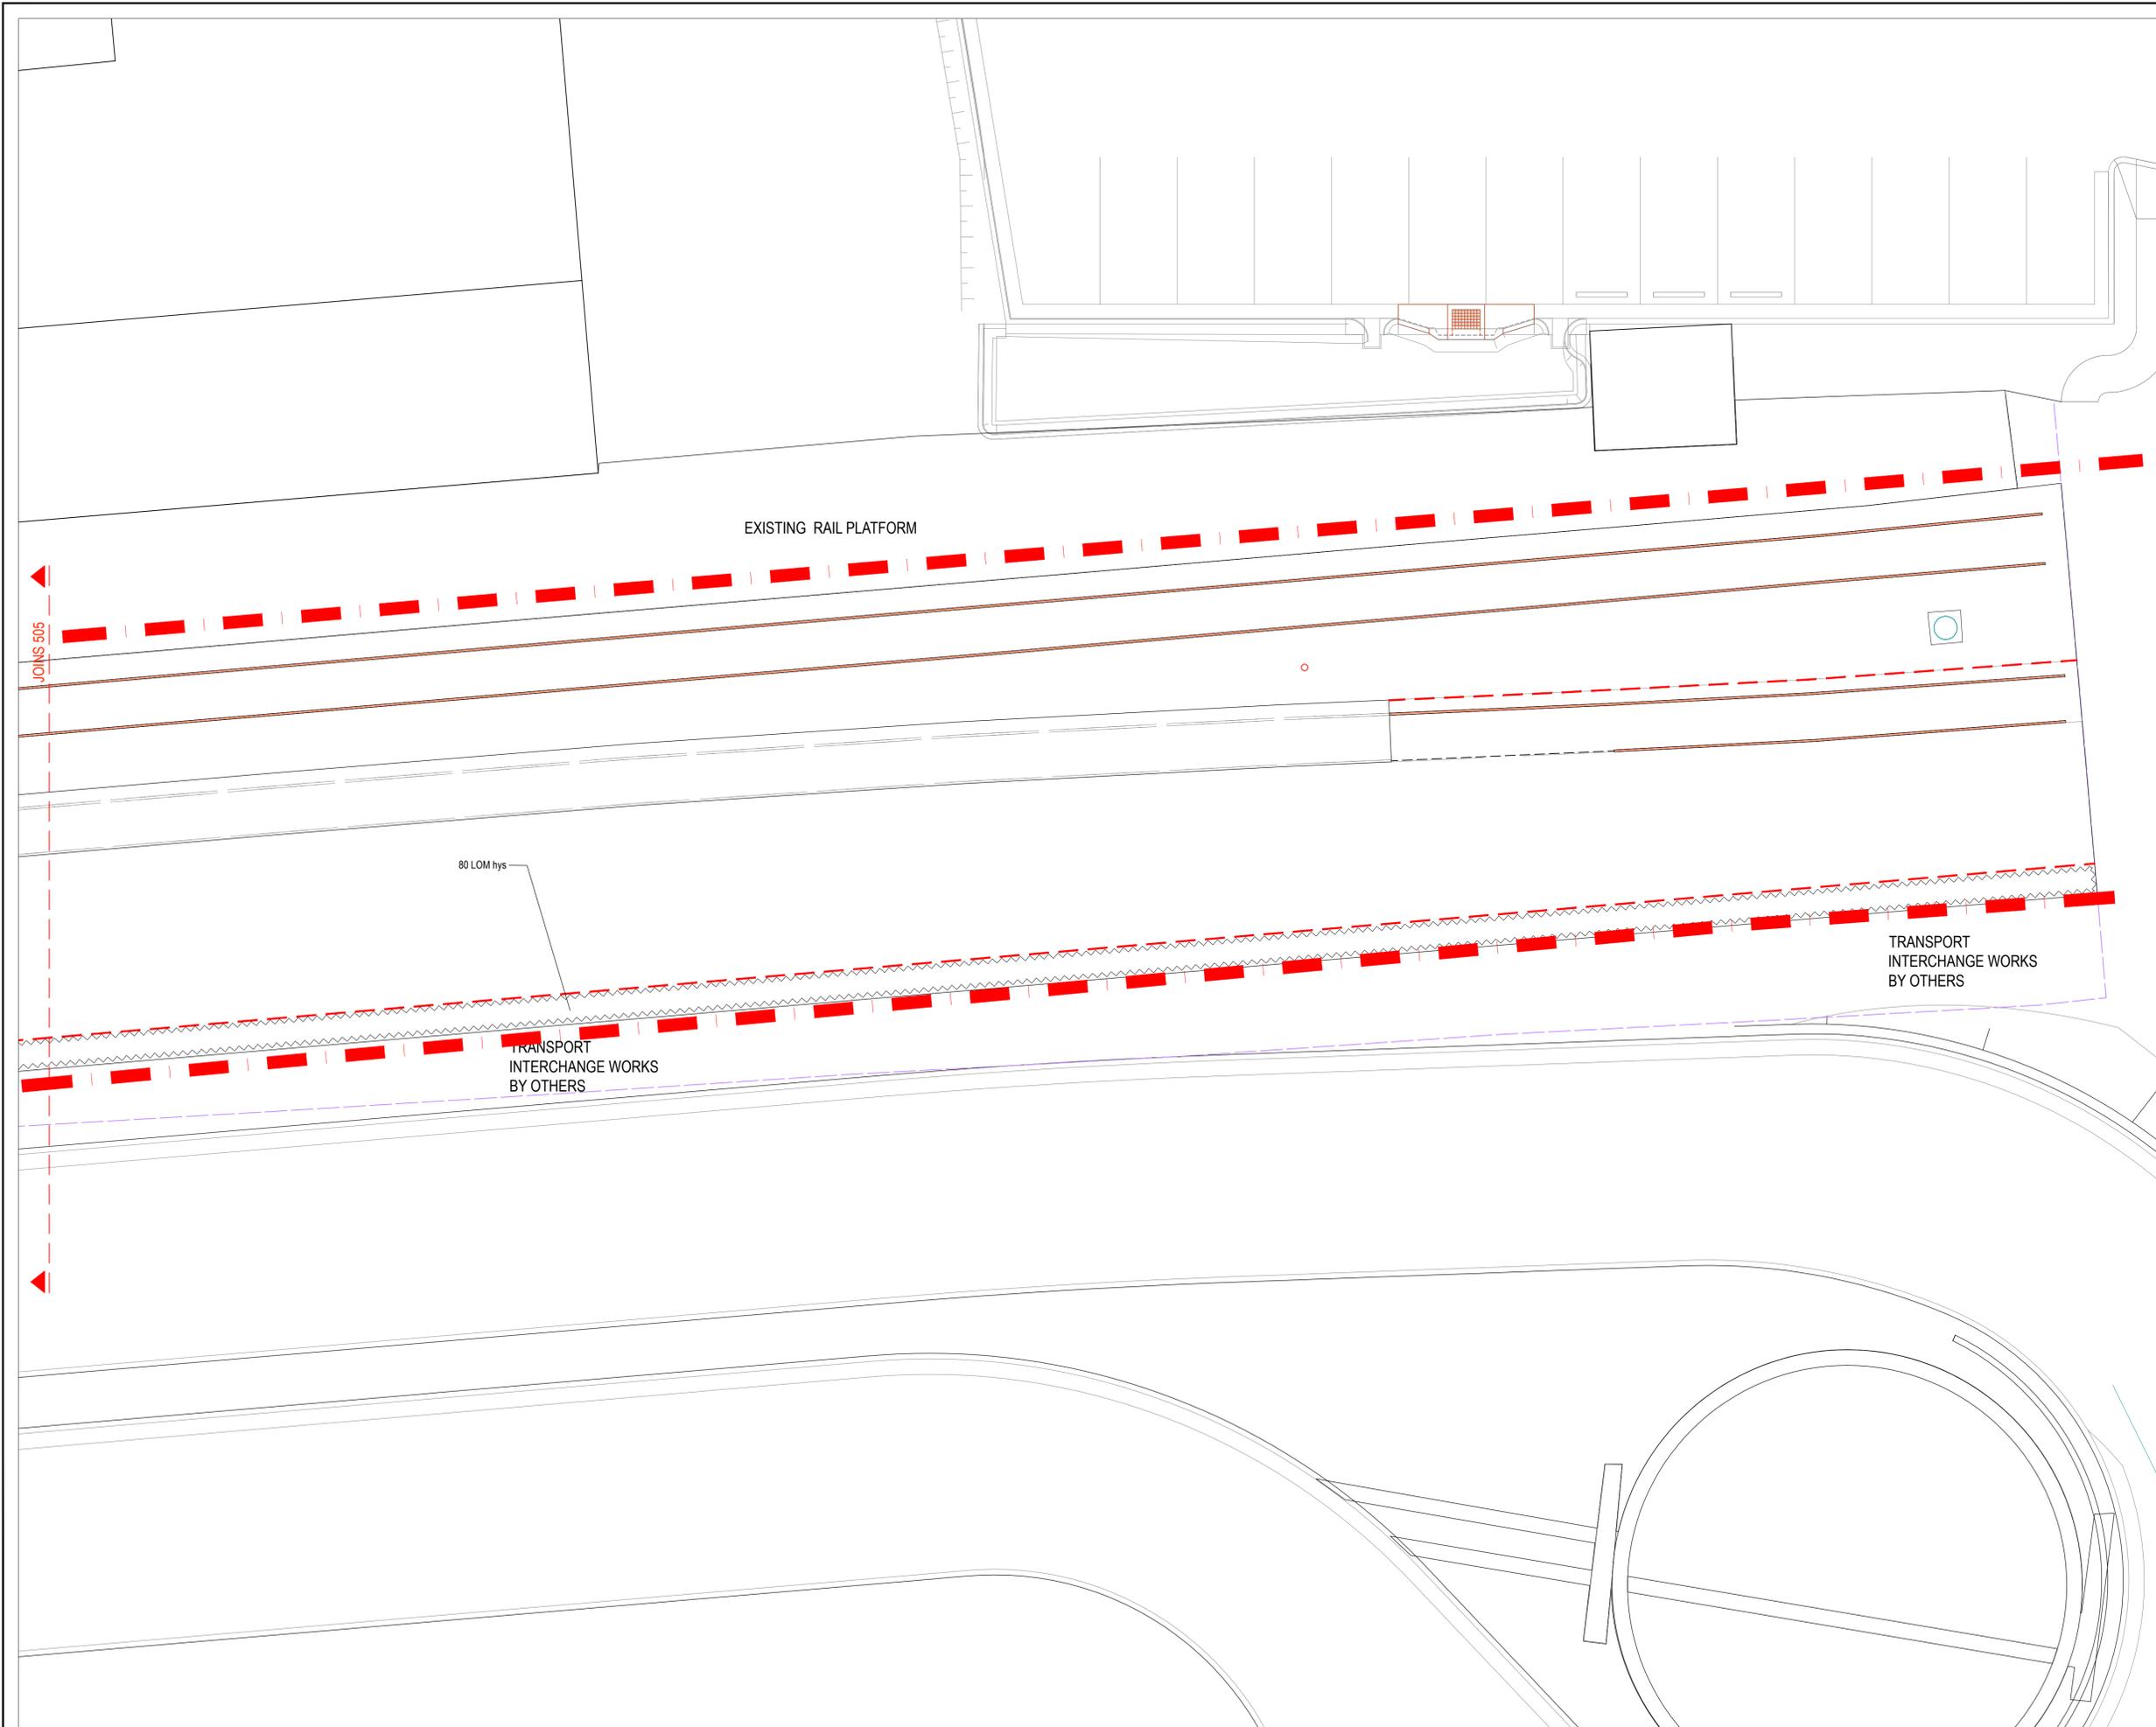

- KEY**
- EXISTING TREE TO BE RETAINED
 - TREE PLANTING
 - PALM PLANTING
 - SHRUBS AND FEATURE PLANTS- REFER TO PLANTING PLANS SCHEDULES.
 - SHRUBS AND FEATURE PLANTS- REFER TO PLANTING PLANS SCHEDULES.
 - HATCHED AND ZIG-ZAG BORDERED AREAS REPRESENT MASS PLANTING AREAS- REFER TO PLANTING PLANS AND PLANT SCHEDULES
 - ROOT BARRIER
 - CONCRETE WALL
 - EXTENT OF WORKS

- NOTES**
1. ENSURE ALL SERVICES ARE LOCATED PRIOR TO COMMENCING LANDSCAPE WORKS

NOTE- THESE WORKS ARE IN A HERITAGE LISTED SITE. EXISTING ARTEFACTS ARE TO BE RETAINED UNLESS EXPLICITLY NOTED OTHERWISE. SEEK APPROVAL PRIOR TO THE DISTURBANCE OF ANY RAIL INFRASTRUCTURE

Revision	Description	Date	Initial
B	FOR TENDER	31.07.20	
A	DRAFT - FOR REVIEW	19.06.20	

1:100 @ A1

PLUMMER & SMITH
 landscape architecture / art / design
 abn: 17 634 944 737 m 0437 599 011
 po box 204 e dar@plummerandsmith.com.au
 murwillumbah NSW 2484 w plummerandsmith.com.au
 © Copyright

BYRON SHIRE COUNCIL
 RAIL CORRIDOR PARK

SOFTWORKS PLANS (SHEET 07 OF 07)

Designed DP	Drawn IW	(paste scanned signature here, preferably use a transparent .png image. Layer order: jpg maps to back, if you must use one)
Checked DP	Approved	
Date 19.06.2020	Scale 1:100	
Job No. 211	Drawing No. 506	Revision B

RAIL CORRIDOR PARK - Plant Schedule

Code	Botanical Name	Common Name	Container Size	Height & Spread at time of planting	Quantity
TREES / PALMS					
*ANG cos L	ANGOPHORA costata	Sydney Red Gum	400 Litre	4m x 2.5m	3
*ANG cos	ANGOPHORA costata	Sydney Red Gum	45 Litre	1.5m x 1m	2
*ARC cun	ARCHONTOPHOENIX cunninghami	Bangalow Palm	45 Litre	2.5m x 1.5m	7
*BAN int	BANKSIA integrifolia	Coastal Banksia	45 Litre	1.5m x 1m	8
*BAN int[200]	BANKSIA integrifolia	Coastal Banksia	200 Litre	3.5m x 2.5m	2
*CUP ana	CUPANIOPSIS anacardioides	Tuckeroo	100 Litre	3.0m x 2.0m	4
*ELA eum	ELAEOCARPUS eumundii	Eumundi Quandong	45 Litre	2m x 1.5m	8
*ELA ret	ELAEOCARPUS reticulatus	Blueberry Ash	45 Litre	1.5m x 1m	4
*FLI sch	FLINDERSIA schottiana	Silver Ash	100 Litre	2.5m x 2.0m	4
*LIV aus	LIVISTONA australis	Cabbage Tree Palm	45 Litre	3m x 1.5m	4
*LOP con	LOPHOSTEMON confertus	Brush Box	45 Litre	1.5m x 1m	1
*LOP sua	LOPHOSTEMON suaveolens	Swamp Box	45 Litre	1.5m x 1m	2
*Mel qui	MELALEUCA quinquenervia	Paperpark	45 Litre	2m x 1.5m	7
*TRI lau L	TRISTANIOPSIS laurina Luscious	Water Gum	200 Litre	3m x 2m	4
SHRUBS / FEATURE PLANTS					
ALO bri	ALOCASIA bribanensis	Cunjevoi	300mm		3
ANI fla	ANIGOZANTHOS flavidus	Kangaroo Paw	140mm		86
AUS dul	AUSTROMYRTUS dulcis	Midgen Berry	140mm		136
BAE vir D	BAEKEA virgata Dwarf	Baekea	140mm		3
BAN rob	BANKSIA robur	Swamp Banksia	140mm		33
CAS gla GW	CASUARINA glauca Green Wave	Green Wave	200mm		60
DOR pal	DORYANTHES palmeri	Gynea Lily	300mm		2
GRE CS	GREVILLEA 'Coastal Sunset'	Grevillea	300mm		16
GRE RG	GREVILLEA 'Robyn Gordon'	Grevillea	300mm		34
LEP pol	LEPTOSPERMUM polygalifolium	Yellow Tea Tree	200mm		30
MEL thy	MELALEUCA thymifolia		140mm		50
OZO dio	OZOTHAMNUS diomifolius	Rice Flower	140mm		80
XAN gla**	XANTHORRHOEA glauca subs. glauca	Grass Tree	300mm		4
GROUNDCOVERS / CLIMBERS / GRASSES					
CAR app	CAREX appressa	Tall Sedge	140mm		20
CAS CI	CASUARINA Cousin It	Cousin It	140mm		166
CHR api	CHRYSOCEPHALUM apiculatum	Yellow Buttons	140mm		83
CIS ant	CISSUS antarctica	Snake Vine	140mm		2
DIA EF	DIANELLA Emerald Fountain	Emerald Fountain	140mm		101
FIC nod	FICINIA nodosa	Knobby Clubrush	140mm		383
LOM hys	LOMANDRA hystrix	Lomandra	Tubestock		483
LOM LT	LOMANDRA Lime Tuff	Lime Tuff	140mm		346
LOM ver	LOMANDRA verday	Verday	140mm		540
POA lab[TS]	POA labillardierei	Common Tussock Grass	Tubestock		28
SCA aem	SCAVOLEA aemulea	Purple Fanflower	140mm		69

*Staked as per detail

** Juvenile (no trunk)

NOTE- THESE WORKS ARE IN A HERITAGE LISTED SITE. EXISTING ARTEFACTS ARE TO BE RETAINED UNLESS EXPLICITLY NOTED OTHERWISE. SEEK APPROVAL PRIOR TO THE DISTURBANCE OF ANY RAIL INFRASTRUCTURE

Revision	Description	Date	Initial
B	FOR TENDER	31.07.20	
A	DRAFT - FOR REVIEW	19.06.20	



@ A1

PLUMMER & SMITH


landscape architecture / art / design
 abn: 17 634 944 737 m 0437 599 011
 po box 204 e dsm@plummerandsmith.com.au
 murwillumbah NSW 2484 w plummerandsmith.com.au
 © Copyright

BYRON SHIRE COUNCIL


RAIL CORRIDOR PARK

SOFTWORKS SCHEDULE


Designed	DP	Drawn	IW	(scanned signature here, preferably use a transparent .png image. Layer order: jpg images to back, if you must use one)
Checked	DP	Approved		
Date	19.06.2020	Scale	-	
Job No.	211	Drawing No.	507	Revision
				B

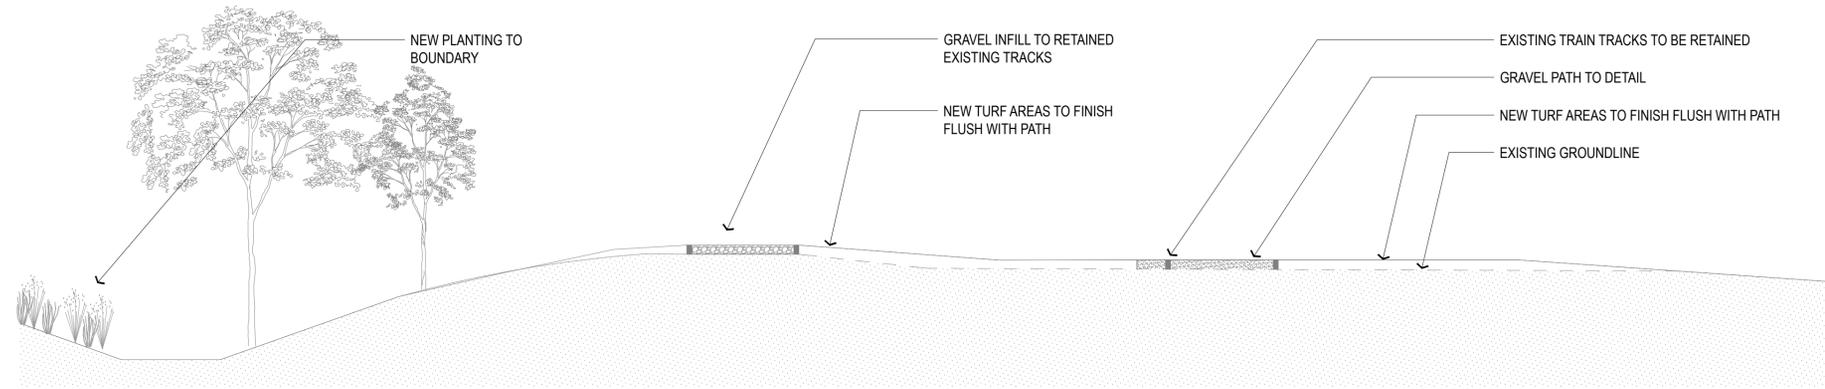


1 CROSS SECTION
600 1:50 @ A1

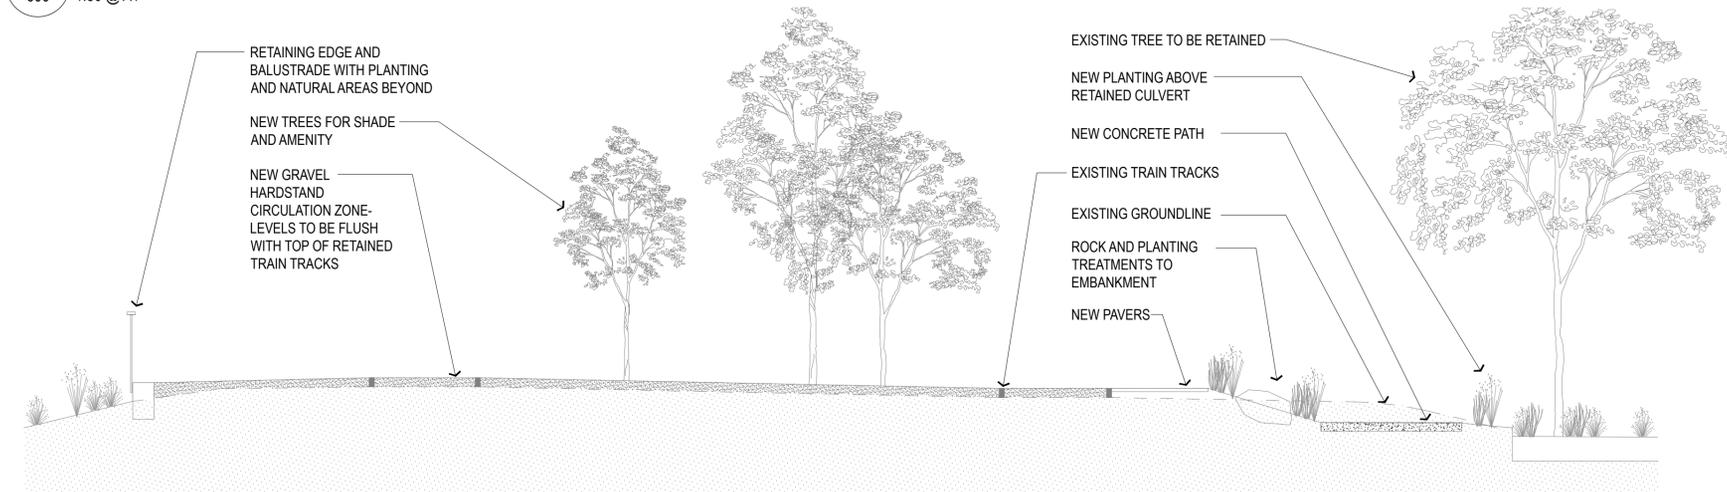

2 CROSS SECTION
600 1:50 @ A1

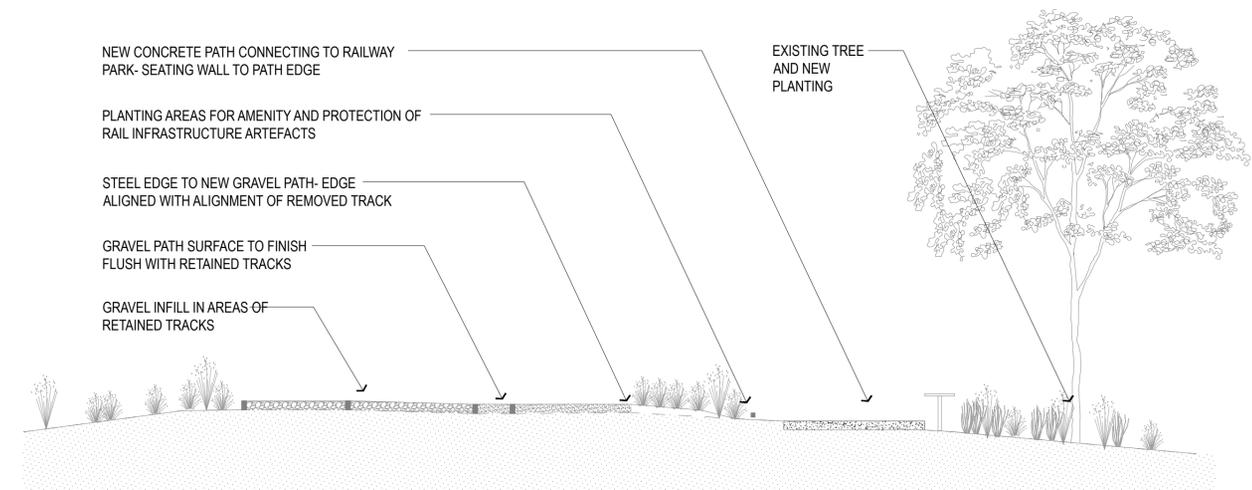

3 CROSS SECTION
600 1:50 @ A1

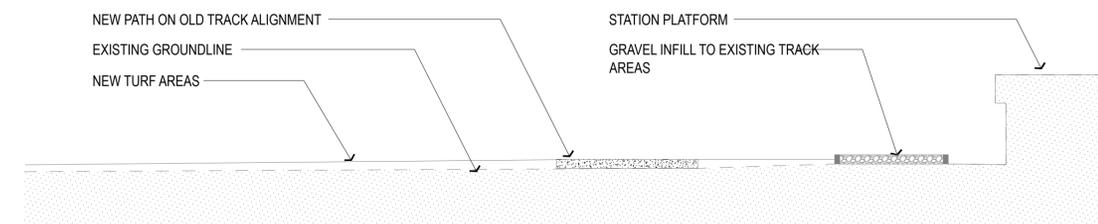

4 CROSS SECTION
600 1:50 @ A1

Revision	Description	Date	Initial
C	FOR TENDER	31.07.20	
B	FINAL DRAFT FOR REVIEW	19.06.20	
A	PRELIMINARY- FOR INFORMATION ONLY	25.05.20	



PLUMMER & SMITH
landscape architecture / art / design
abn: 17 634 944 737 m 0437 599 011
po box 204 e dan@plummerandsmith.com.au
munwillumbah NSW 2484 w plummerandsmith.com.au
© Copyright

BYRON SHIRE COUNCIL

RAIL CORRIDOR PARK

CROSS SECTIONS

Designed	DP	Drawn	DP
Checked	DP	Approved	
Date	25.05.2020	Scale	AS SHOWN
Job No.	211	Drawing No.	600
		Revision	C



PRODUCT NAME	FLIP SEAT
PRODUCT SUPPLIER	MOS URBAN
PRODUCT CODE	NA
PRODUCT FINISH	TIMBER- HARDWOOD, STEEL- POWDERCOATED
PRODUCT COLOUR	TIMBER- SELECTED HARDWOOD, STEEL POWDERCOAT- STROMBOLI
PRODUCT FIXING	SURFACE FIXED TO MANUFACTURERS RECOMMENDATIONS

1 TIMBER BACKREST SEAT
900



PRODUCT NAME	MACQUARIE BIN ENCLOSURE (DOUBLE- WASTE AND RECYCLING)
PRODUCT SUPPLIER	GOSSI PARK (PH: 07 3877 2856)
PRODUCT CODE	TO MATCH PREVIOUSLY PROVIDE BYRON BAY BINS
PRODUCT FINISH	ALUMINIUM
PRODUCT COLOUR	ALUMINIUM
PRODUCT FIXING	SURFACE FIXED TO MANUFACTURERS RECOMMENDATIONS

3 BIN ENCLOSURE
900




PRODUCT NAME	SEMI-HOOP
PRODUCT SUPPLIER	STREET FURNITURE AUSTRALIA (PH: 1300 027 799)
PRODUCT CODE	BST03
PRODUCT FINISH	STAINLESS 304 NO.4 FINISH (BRUSHED)
PRODUCT COLOUR	NA
PRODUCT FIXING	SUB-SURFACE FIXED TO MANUFACTURERS RECOMMENDATIONS

2 SEMI-HOOP BICYCLE STAND
900 NA




PRODUCT NAME	AQUAFIL
PRODUCT SUPPLIER	CIVIQ (SUPPLY BY BYRON SHIRE COUNCIL)
PRODUCT CODE	2100 BF (X1), 1200 BF (X1)
PRODUCT FINISH	
PRODUCT COLOUR	
PRODUCT FIXING	INSTALLED TO MANUFACTURERS RECOMMENDATIONS


4 WATER REFILL STATION
900 NA

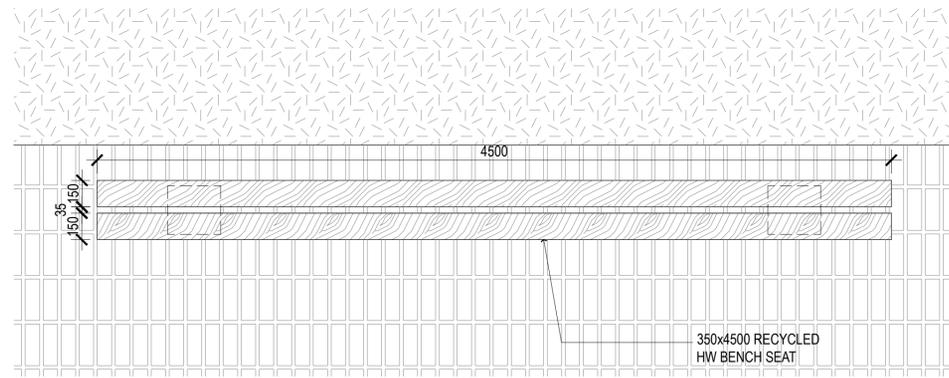

5 CUSTOM TIMBER BENCH SEAT - PLAN
900 1:20 @ A1

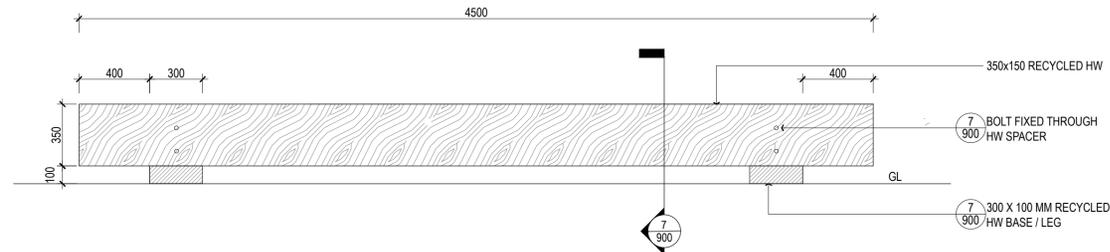

6 CUSTOM TIMBER BENCH SEAT - ELEVATION
900 1:20 @ A1

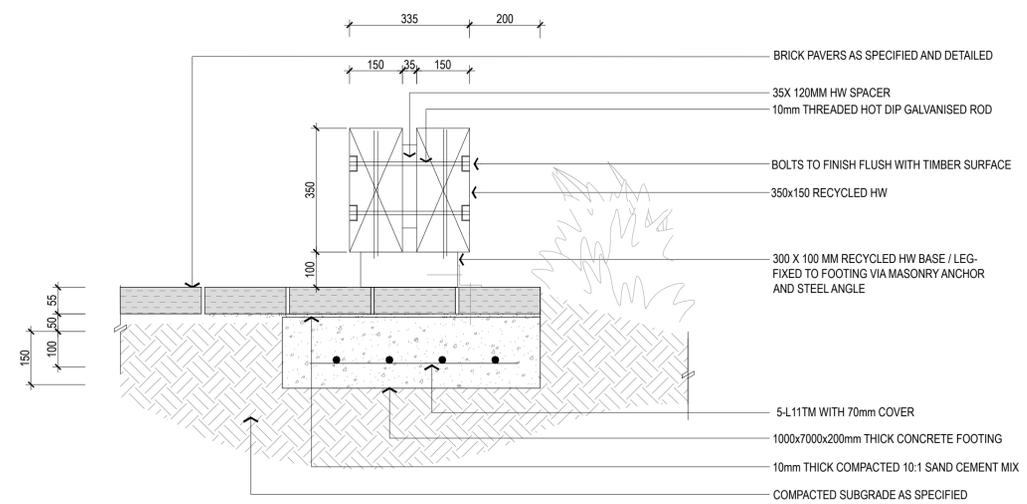

7 CUSTOM TIMBER BENCH SEAT - SECTION
900 1:10 @ A1

C	FOR TENDER	31.07.20
B	FINAL DRAFT FOR REVIEW	19.06.20
A	PRELIMINARY- FOR INFORMATION ONLY	25.05.20


AS SHOWN @ A1

PLUMMER & SMITH
landscape architecture / art / design
abr: 17 634 944 737 m 0437 599 011
po box 204 e dan@plummerandsmith.com.au
munwilmah NSW 2484 w plummerandsmith.com.au
© Copyright


BYRON SHIRE COUNCIL
RAIL CORRIDOR PARK

CONSTRUCTION DETAILS


Designed	DP	Drawn	EC
Checked	DP	Approved	
Date	25.05.2020	Scale	AS SHOWN
Job No.	211	Drawing No.	900
		Revision	C

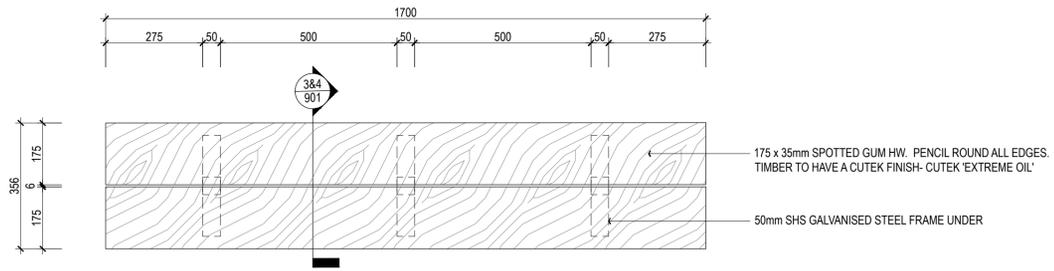


1 CUSTOM TIMBER BENCH SEAT - PLAN
901 1:10 @ A1

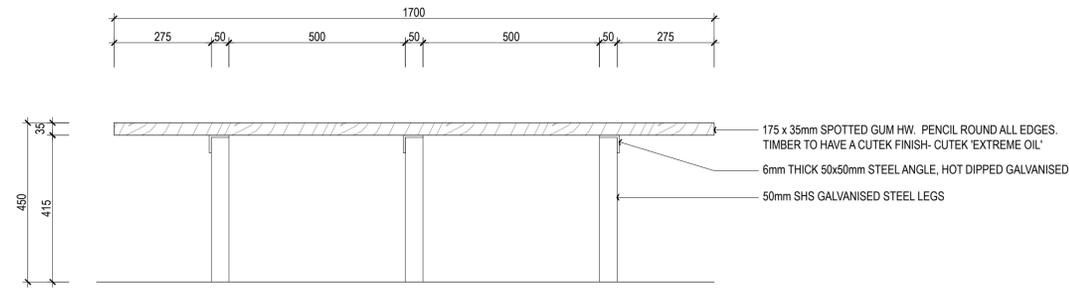


2 CUSTOM TIMBER BENCH SEAT - ELEVATION
901 1:10 @ A1

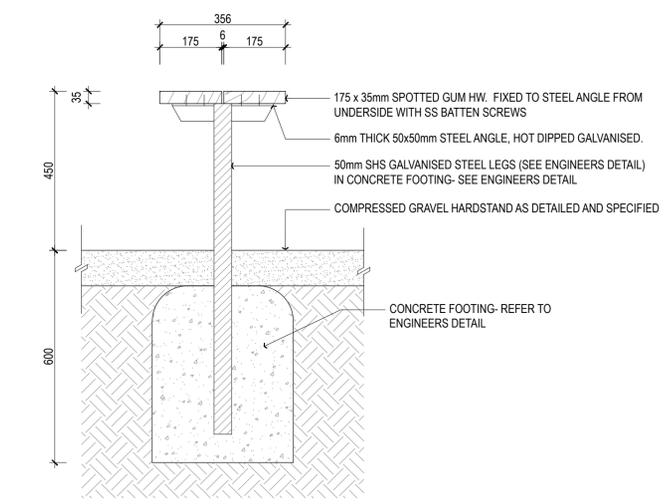


3 CUSTOM TIMBER BENCH SEAT - SECTION IN COMPRESSED GRAVEL
901 1:10 @ A1

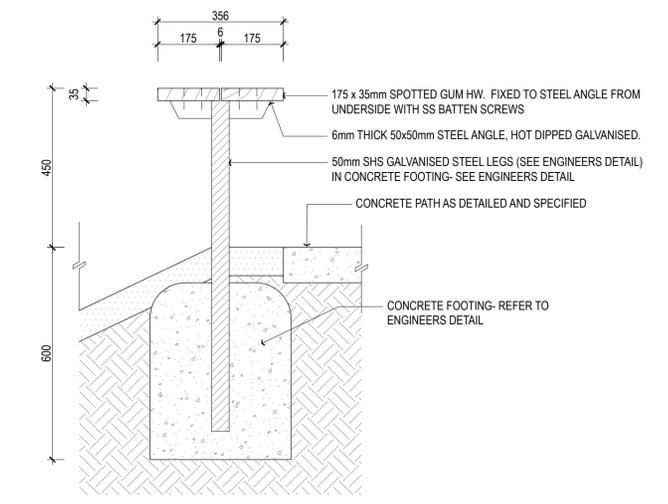


4 CUSTOM TIMBER BENCH SEAT - SECTION IN PLANTING AT PATH EDGE
901 1:10 @ A1

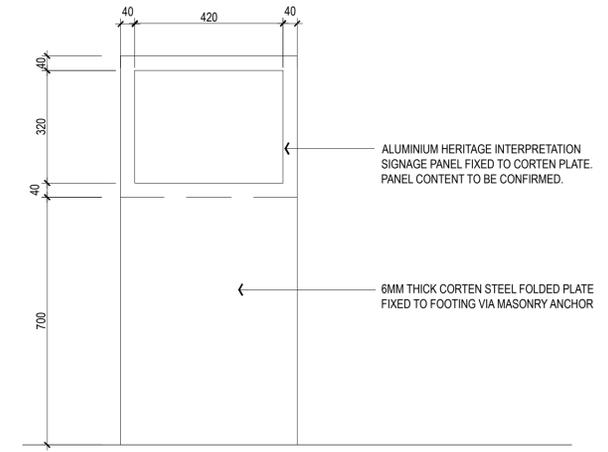

ELEVATION

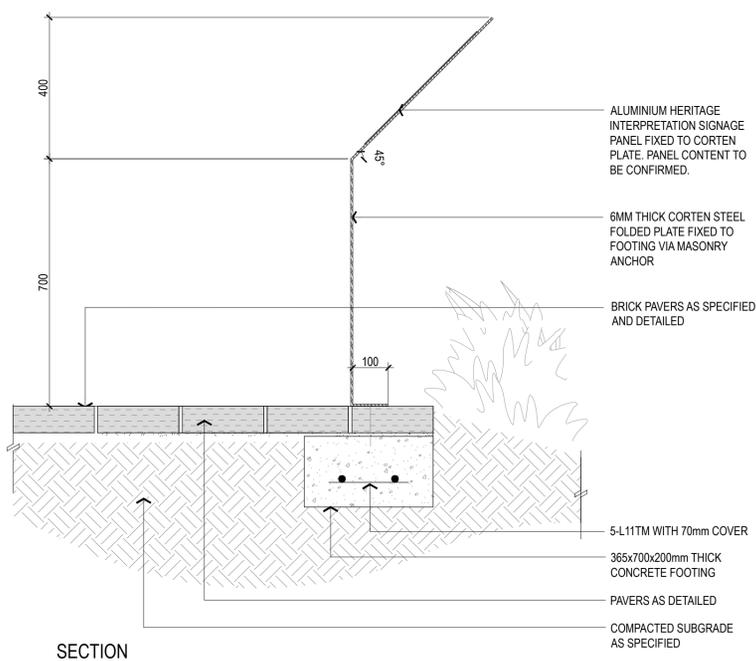

5 INTERPRETIVE PANEL
901 1:10 @ A1

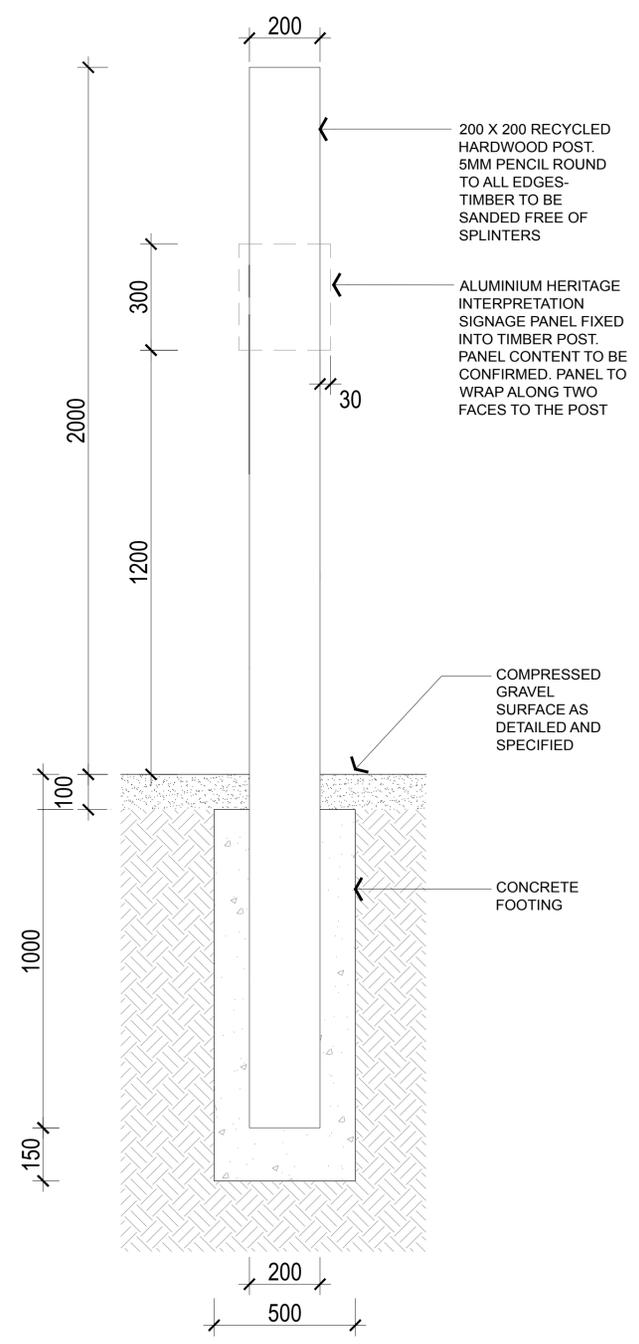

6 INTERPRETATION POST
901 1:10 @ A1

Revision	Description	Date	Initial
C	FOR TENDER	31.07.20	
B	FINAL DRAFT FOR REVIEW	19.06.20	
A	PRELIMINARY- FOR INFORMATION ONLY	25.05.20	




AS SHOWN @ A1

PLUMMER & SMITH
landscape architecture / art / design
abr: 17 634 944 737 m 0437 599 011
po box 204 e dan@plummerandsmith.com.au
munwillumbah NSW 2484 w plummerandsmith.com.au
© Copyright

BYRON SHIRE COUNCIL
RAIL CORRIDOR PARK



CONSTRUCTION DETAILS

Designed	DP	Drawn	EC
Checked	DP	Approved	
Date	25.05.2020	Scale	AS SHOWN
Job No.	211	Drawing No.	901
		Revision	C

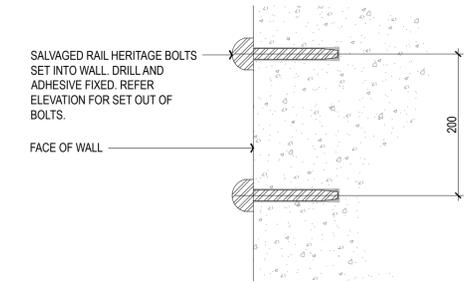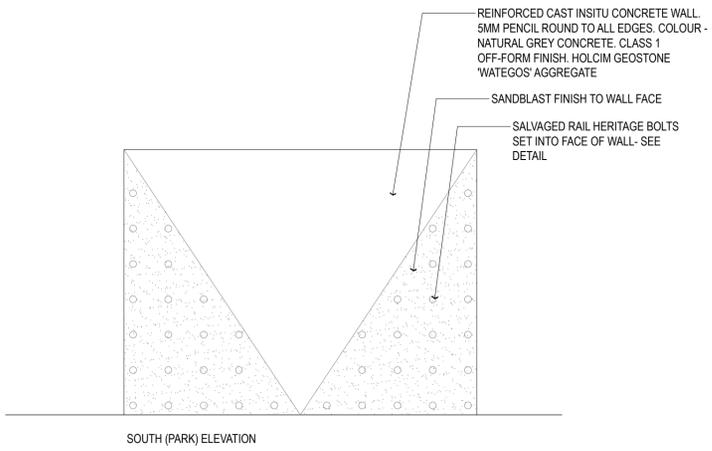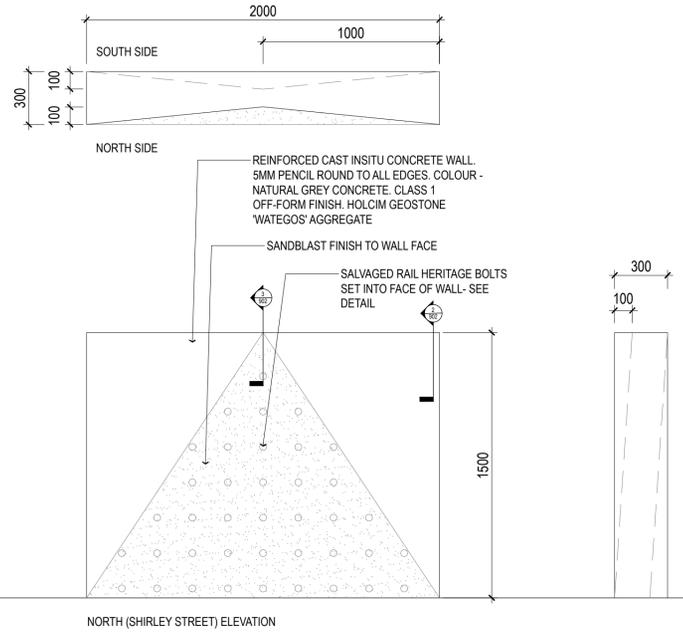



1 FEATURE WALL - PLAN & ELEVATION
902 1:40 @ A1

4 SALVAGED RAIL BOLTS DETAIL - SECTION
902 1:5

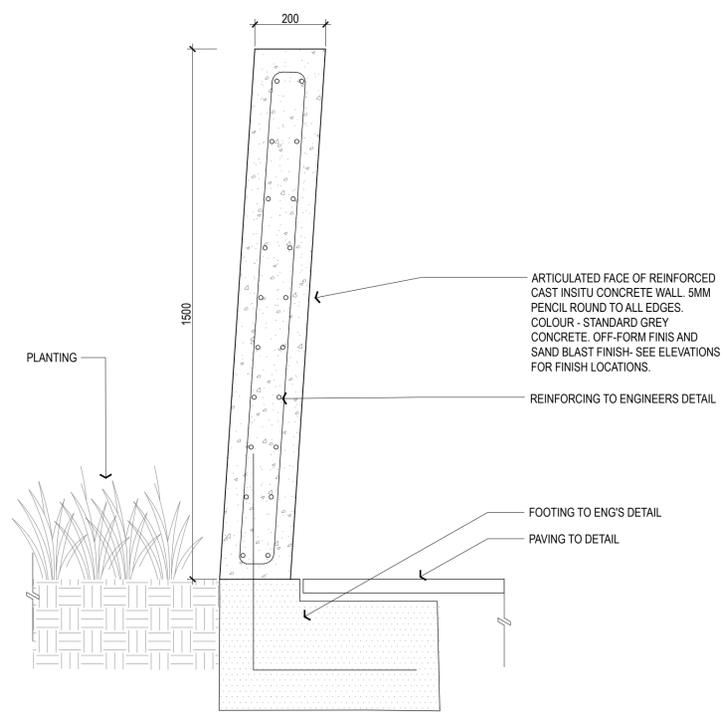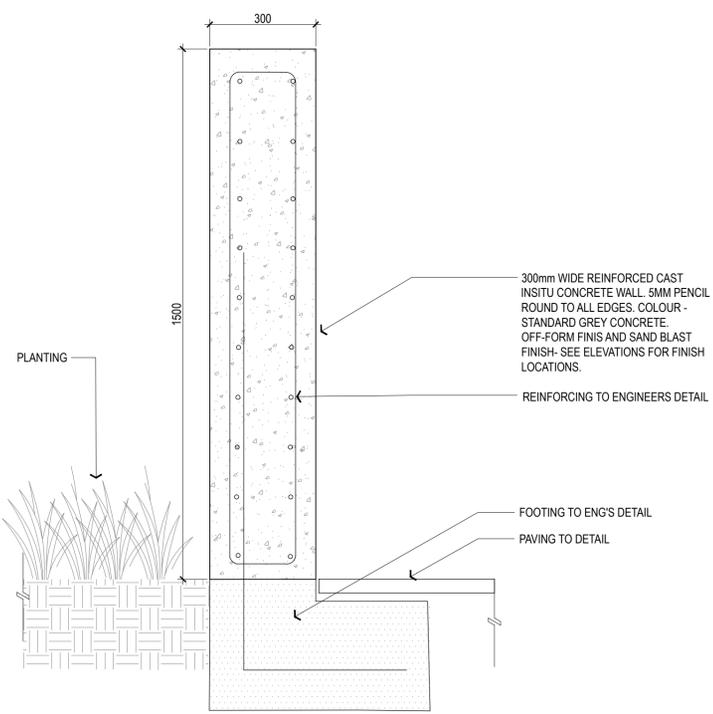

2 FEATURE WALL - SECTION
902 1:10 @ A1

3 FEATURE WALL - SECTION
902 1:10 @ A1

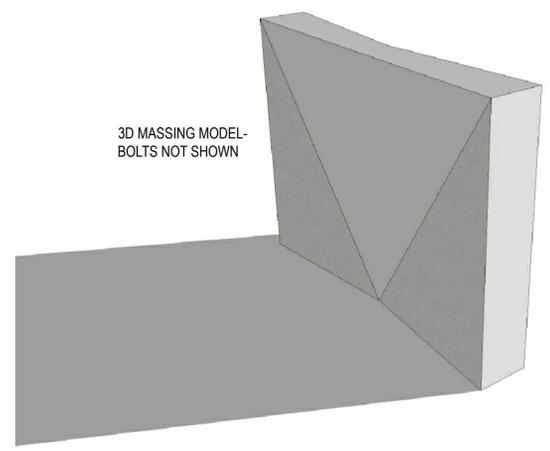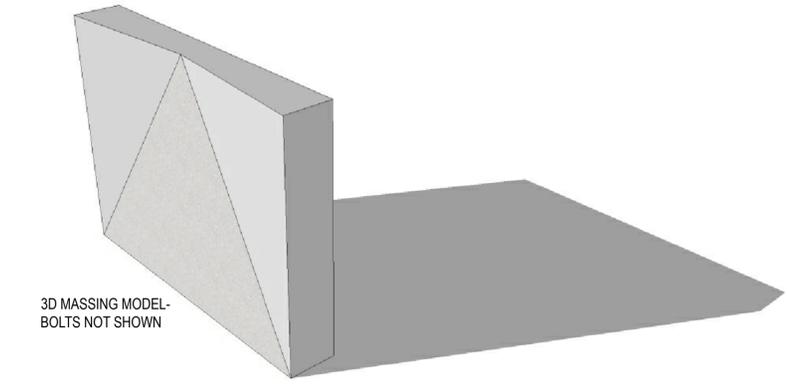

5 FEATURE WALL - 3D'S
902 NA

Revision	Description	Date	Initial
C	FOR TENDER	31.07.20	
B	FINAL DRAFT FOR REVIEW	19.06.20	
A	PRELIMINARY- FOR INFORMATION ONLY	25.05.20	


AS SHOWN @ A1

PLUMMER & SMITH
landscape architecture / art / design
abn: 17 634 944 737 m 0437 599 011
po box 204 e dan@plummerandsmith.com.au
munwilmah NSW 2484 w plummerandsmith.com.au
© Copyright


BYRON SHIRE COUNCIL
RAIL CORRIDOR PARK

CONSTRUCTION DETAILS


Designed DP	Drawn EC
Checked DP	Approved
Date 25.05.2020	Scale AS SHOWN
Job No. 211	Drawing No. 902 Revision C

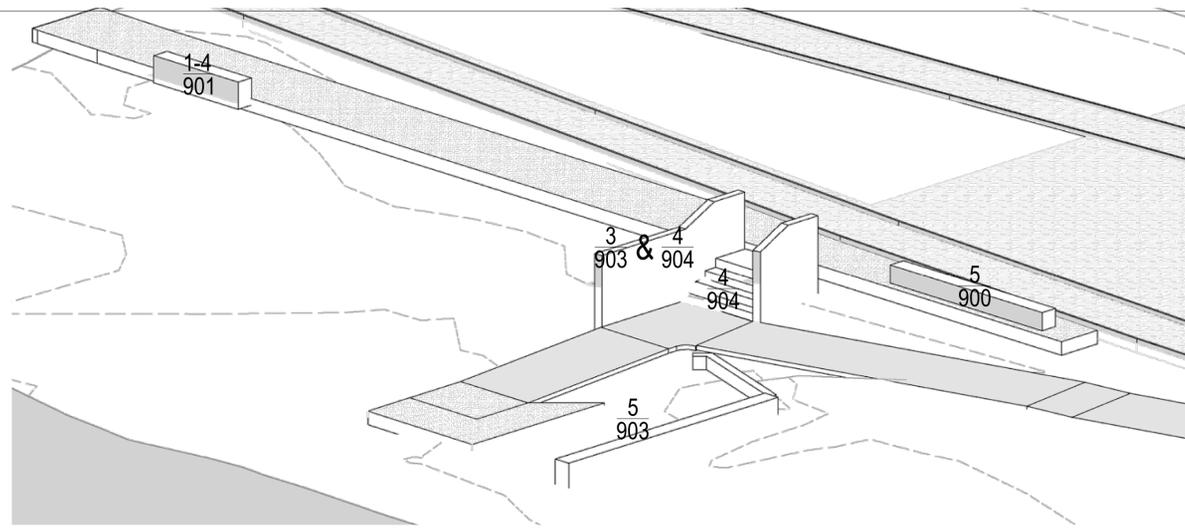


1 INDICATIVE 3D PERSPECTIVE
903 NTS @ A1

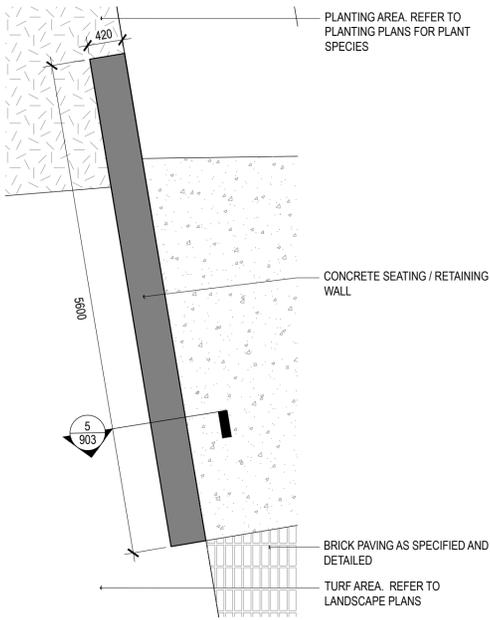


2 CONCRETE SEATING WALL - PLAN
903 1:40 @ A1

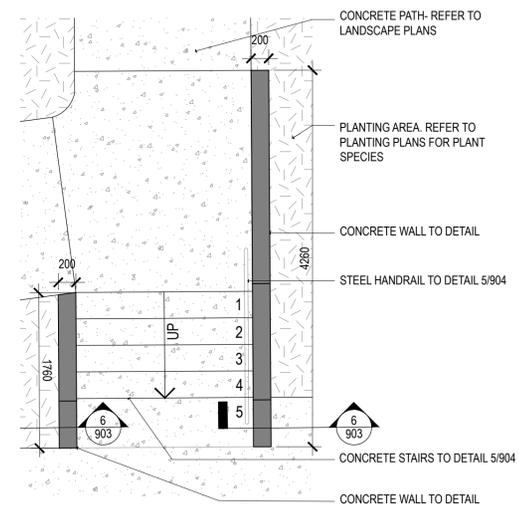


3 CONCRETE WALL TO STAIR - PLAN
903 1:40 @ A1

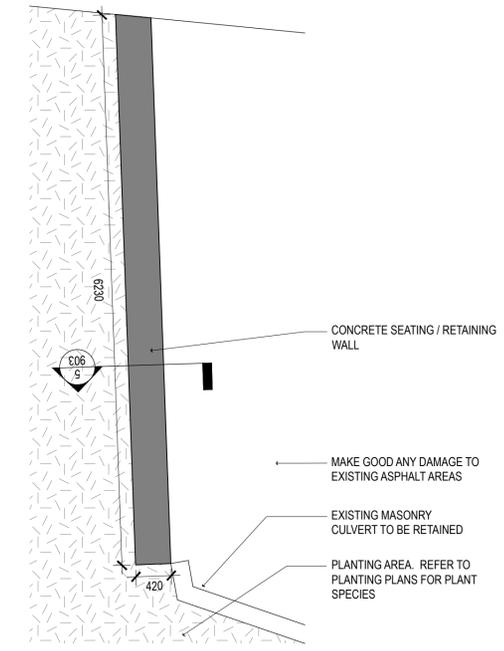

4 CONCRETE SEATING WALL - PLAN
903 1:40 @ A1

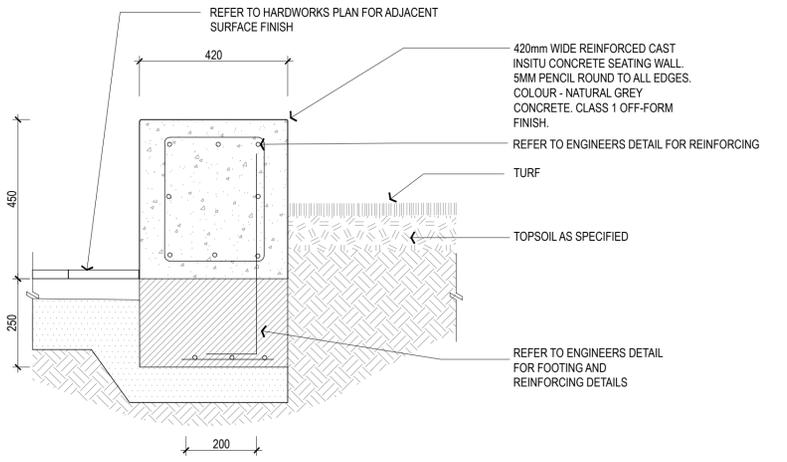


5 CONCRETE SEATING WALL - SECTION
903 1:10 @ A1

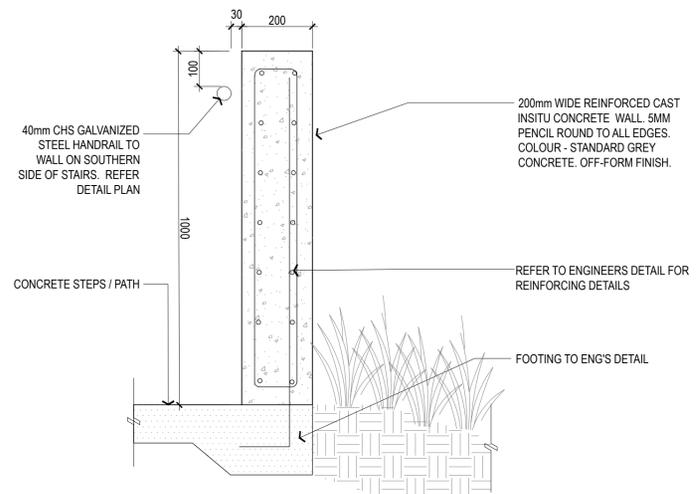

6 CONCRETE WALL - SECTION
903 1:10 @ A1

Revision	Description	Date	Initial
C	FOR TENDER	31.07.20	
B	FINAL DRAFT FOR REVIEW	19.06.20	
A	PRELIMINARY- FOR INFORMATION ONLY	25.05.20	

 


PLUMMER & SMITH
landscape architecture / art / design
abn: 17 634 944 737 m 0437 599 011
po box 204 e dan@plummerandsmith.com.au
munwilmah NSW 2484 w plummerandsmith.com.au
© Copyright


BYRON SHIRE COUNCIL
RAIL CORRIDOR PARK

CONSTRUCTION DETAILS


Designed DP	Drawn EC
Checked DP	Approved
Date 25.05.2020	Scale AS SHOWN
Job No. 211	Drawing No. 903 Revision C

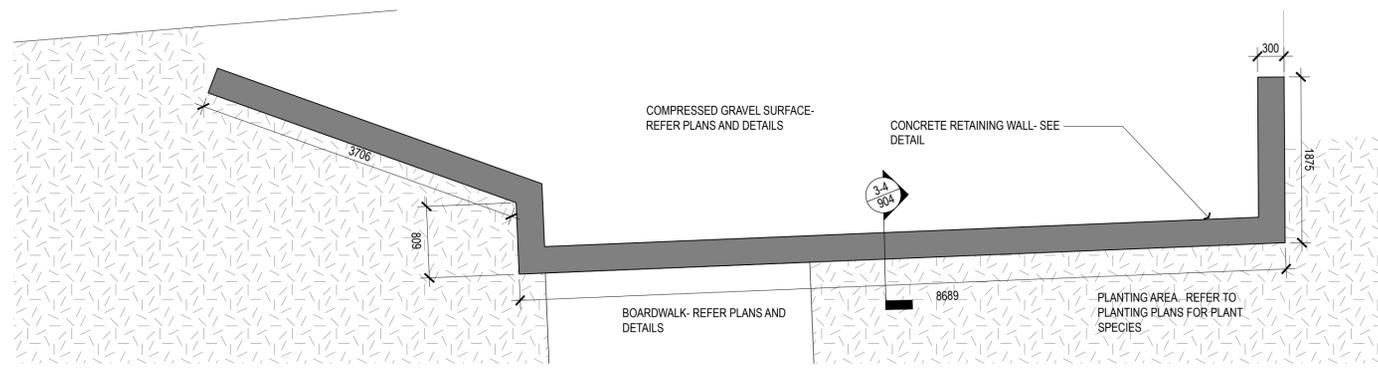


1 CONCRETE RETAINING WALL - PLAN
904 1:40 @ A1

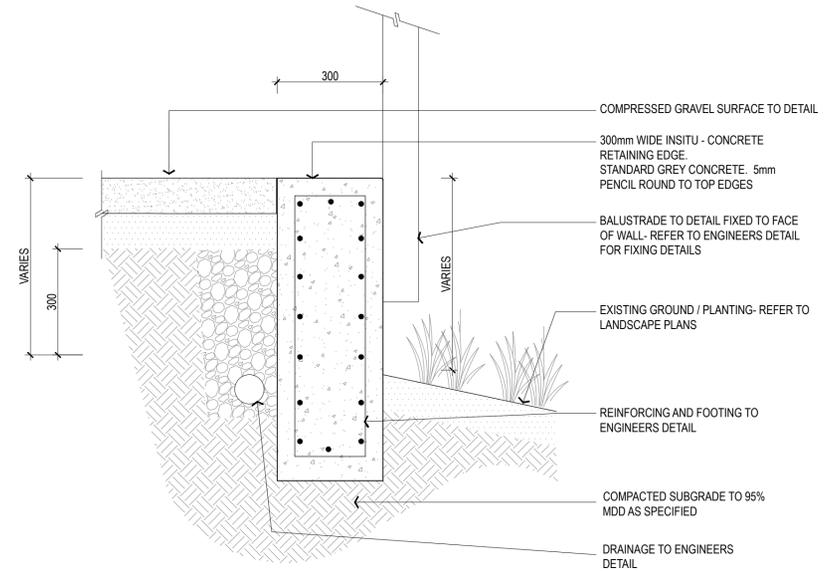


4 CONCRETE RETAINING WALL 2 - SECTION
904 1:10 @ A1

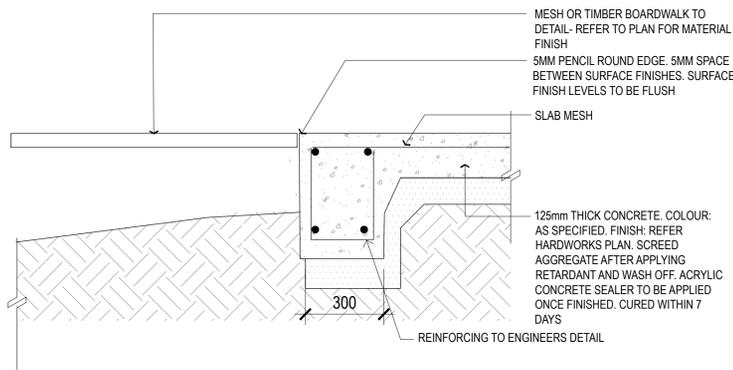

2 CONCRETE EDGE THICKENING / TURNDOWN - SECTION
904 1:10 @ A1

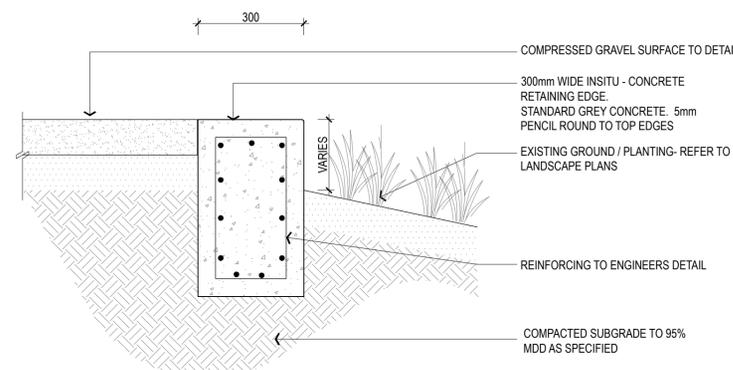

3 CONCRETE RETAINING WALL - SECTION
904 1:10 @ A1

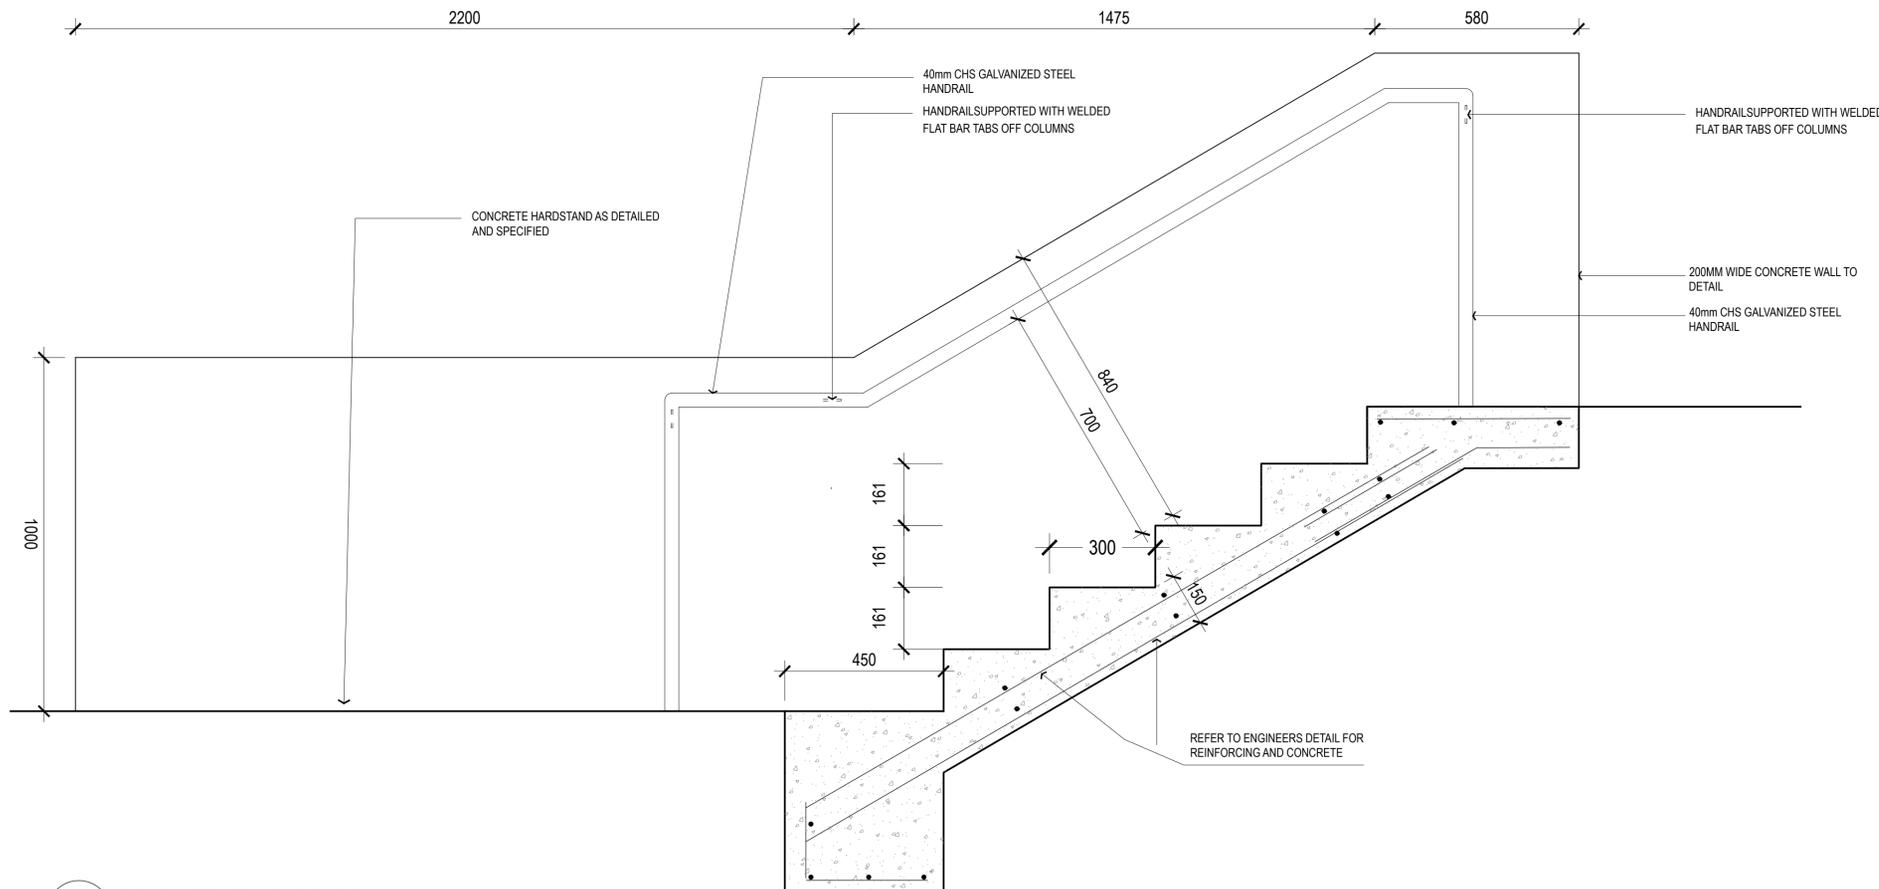

5 CONCRETE STAIR- SECTION
904 1:10 @ A1

Revision	Description	Date	Initial
C	FOR TENDER	31.07.20	
B	FINAL DRAFT FOR REVIEW	19.06.20	
A	PRELIMINARY- FOR INFORMATION ONLY	25.05.20	


AS SHOWN @ A1

PLUMMER & SMITH
landscape architecture / art / design
abn: 17 634 944 737 m 0437 599 011
po box 204 e dan@plummerandsmith.com.au
munwillumbah NSW 2484 w plummerandsmith.com.au
© Copyright


BYRON SHIRE COUNCIL
RAIL CORRIDOR PARK

CONSTRUCTION DETAILS


Designed DP	Drawn EC
Checked DP	Approved
Date 25.05.2020	Scale AS SHOWN
Job No. 211	Drawing No. 904 Revision C

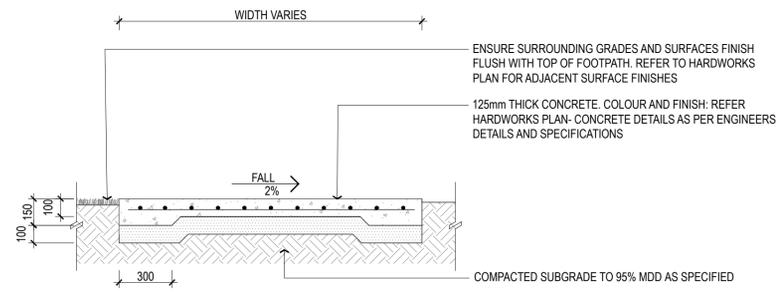


1 125mm THICK REINFORCED CONCRETE HARDSTAND
905 1:20 @ A1

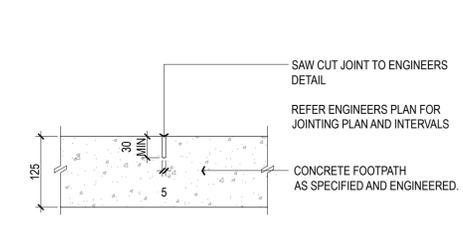


2 TYPICAL SAW CUT JOINT
905 1:5 @ A1

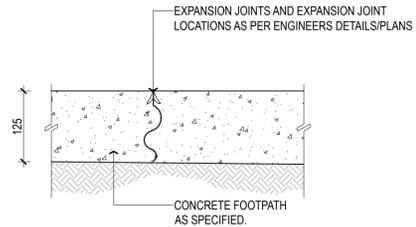


3 TYPICAL EXPANSION JOINT
905 1:5 @ A1

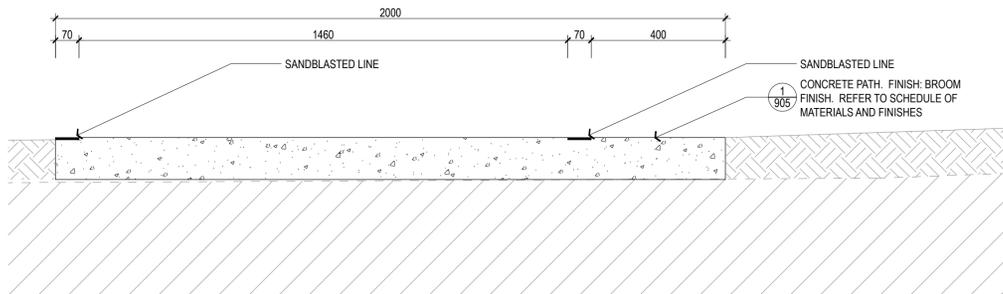


4 125mm THICK REINFORCED CONCRETE PATH WITH SANDBLASTING
905 1:20 @ A1

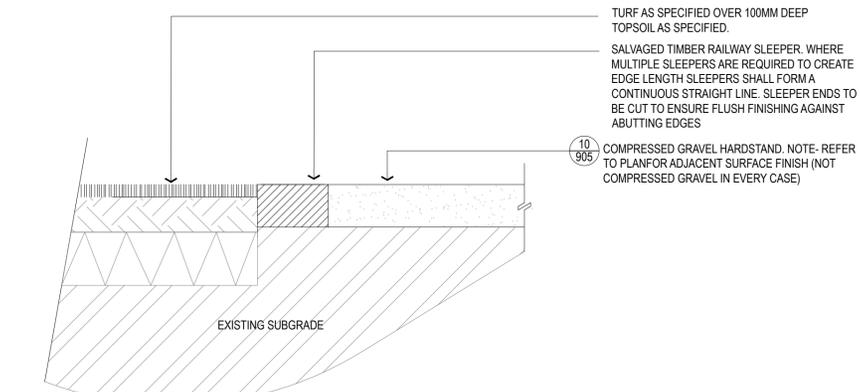


5 TIMBER SLEEPER EDGE
905 1:10 @ A1

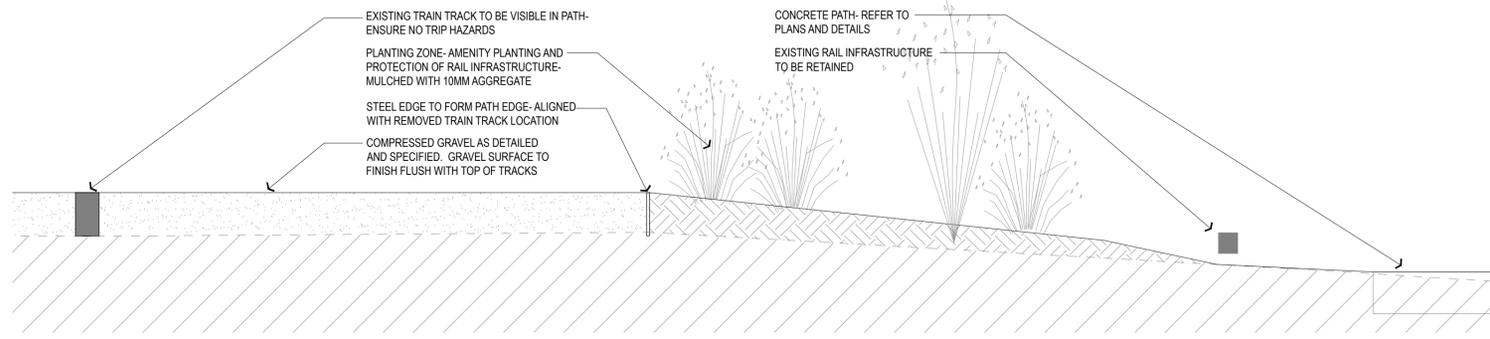

6 COMPRESSED GRAVEL PATH WITH STEEL EDGE AND PLANTING WITHIN RAIL INFRASTRUCTURE- SECTION
905 1:20 @ A1

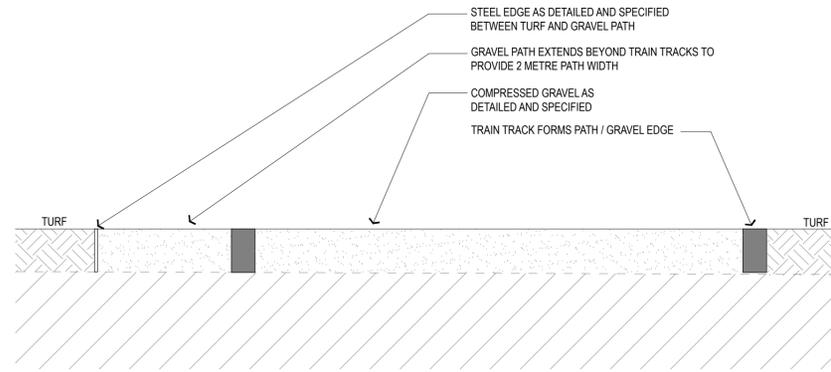


7 COMPRESSED GRAVEL PATH AND TRAIN TRACKS- SECTION
905 1:20 @ A1

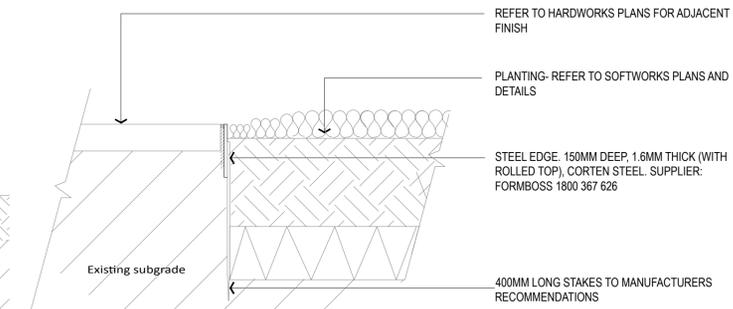


NOTES:
1. CULTIVATE EXISTING SUBGRADE TO A DEPTH OF 150MM MIN.
2. TOPSOIL- SUPPLY AND INSTALL 100MM DEEP TOPSOIL FOR TURF AREAS. SITE SOIL USED ONLY AS APPROVED.
3. VARYING STEEL EDGE PROFILES USED- 150, 390, 580. REFER TO PLAN FOR LOCATIONS. INSTALL TO MANUFACTURERS SPECIFICATIONS.


8 STEEL EDGE
905 1:10 @ A1

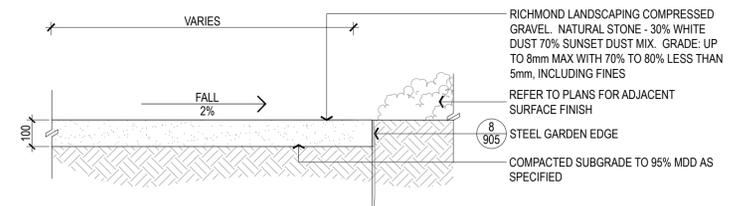

10 COMPRESSED GRAVEL HARDSTAND
905 1:10 @ A1

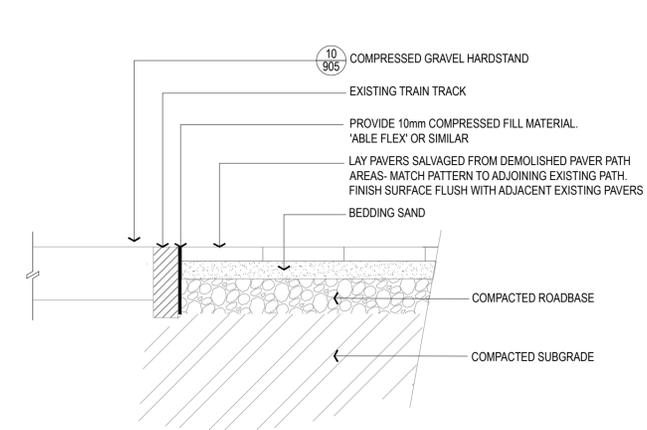

9 BRICK PAVING
905 1:10 @ A1

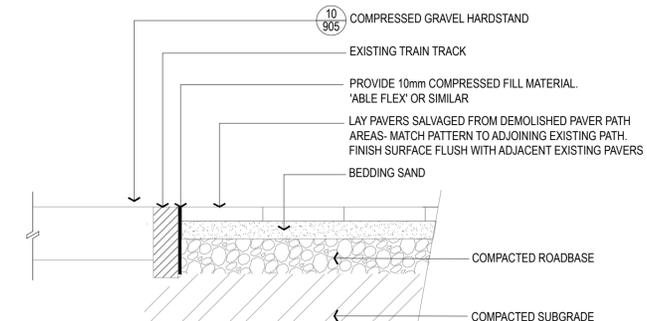

10 COMPRESSED GRAVEL HARDSTAND
905 1:10 @ A1

Revision	Description	Date	Initial
C	FOR TENDER	31.07.20	
B	FINAL DRAFT FOR REVIEW	19.06.20	
A	PRELIMINARY- FOR INFORMATION ONLY	25.05.20	


AS SHOWN @ A1

PLUMMER & SMITH
landscape architecture / art / design
abr: 17 634 944 737 m 0437 599 011
po box 204 e dan@plummerandsmith.com.au
munwillumbah NSW 2484 w plummerandsmith.com.au
© Copyright


BYRON SHIRE COUNCIL
RAIL CORRIDOR PARK

CONSTRUCTION DETAILS


Designed	DP	Drawn	EC
Checked	DP	Approved	
Date	25.05.2020	Scale	AS SHOWN
Job No.	211	Drawing No.	905
		Revision	C

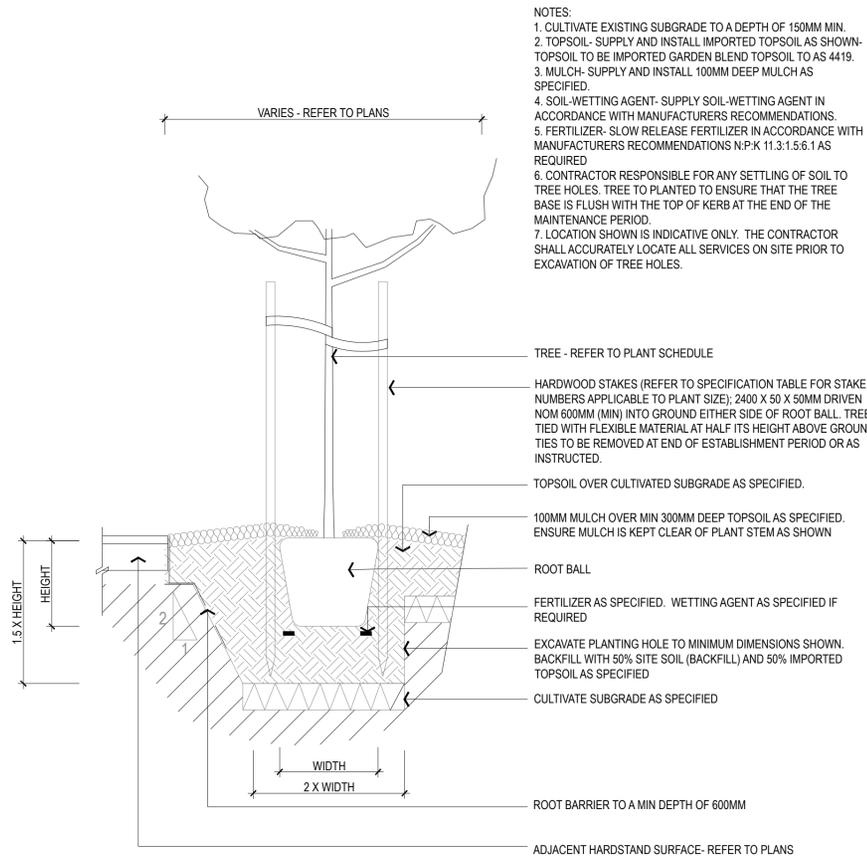


1 TYPICAL TREE PLANTING IN GARDEN - SECTION & PLAN
906 1:20 @ A1

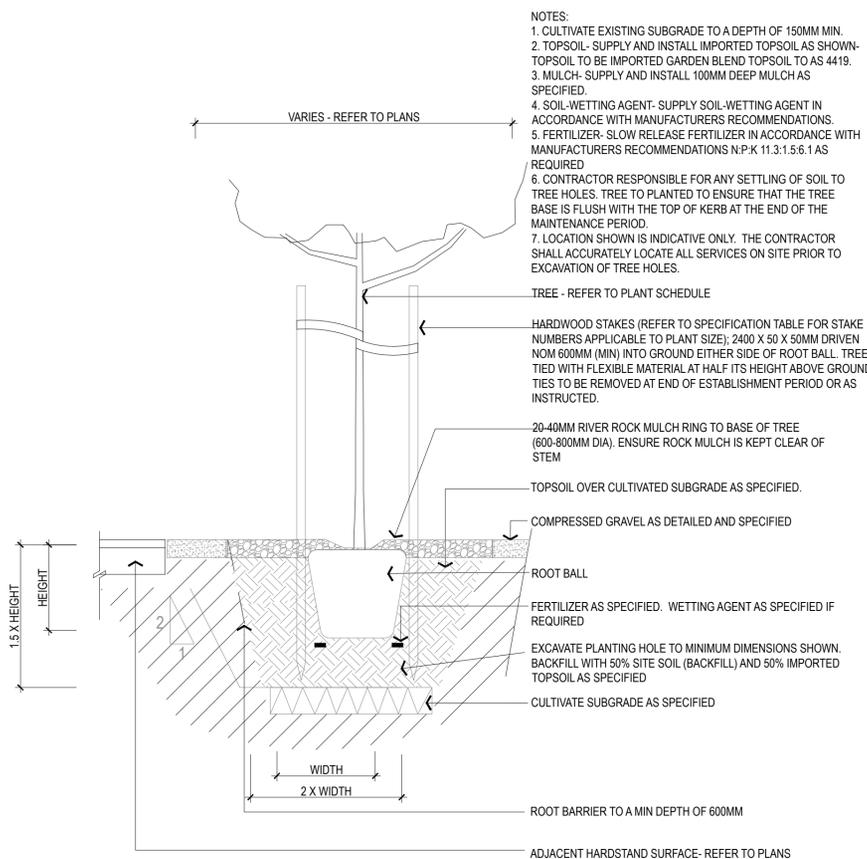


4 TYPICAL TREE PLANTING IN COMPRESSED GRAVEL - SECTION & PLAN
906 1:20 @ A1

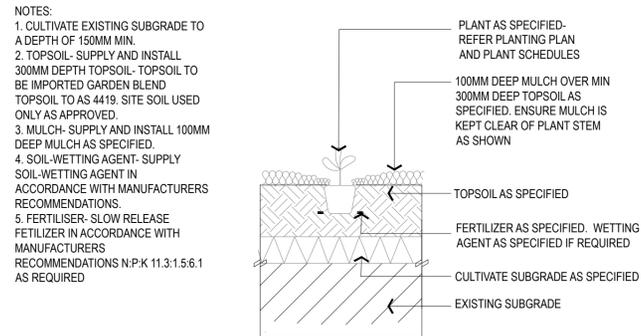

2 TYPICAL PLANTING GROUNDCOVER/ SHRUB - SECTION
906 1:20 @ A1

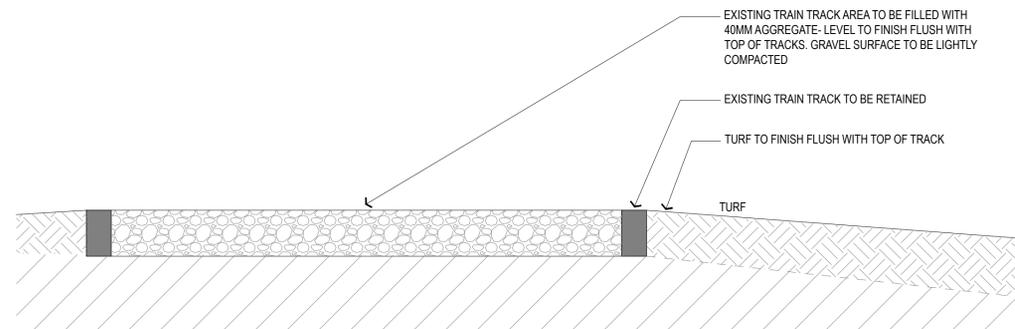

5 GRAVEL INFILL IN TRACKS - LEVEL WITH TRACKS- SECTION
906 1:20

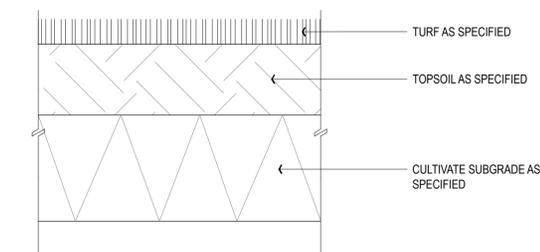

3 TURF - SECTION
906 1:5 @ A1

Revision	Description	Date	Initial
C	FOR TENDER	31.07.20	
B	FINAL DRAFT FOR REVIEW	19.06.20	
A	PRELIMINARY- FOR INFORMATION ONLY	25.05.20	



PLUMMER & SMITH
landscape architecture / art / design
abn: 17 634 944 737 m 0437 599 011
po box 204 e dan@plummerandsmith.com.au
munwillumbah NSW 2484 w plummerandsmith.com.au
© Copyright


BYRON SHIRE COUNCIL

RAIL CORRIDOR PARK


CONSTRUCTION DETAILS

Designed DP	Drawn EC
Checked DP	Approved
Date 25.05.2020	Scale AS SHOWN
Job No. 211	Drawing No. 906
Revision	C


- NOTES:
1. CULTIVATE EXISTING SUBGRADE TO A DEPTH OF 150MM MIN.
 2. TOPSOIL- SUPPLY AND INSTALL IMPORTED TOPSOIL AS SHOWN. TOPSOIL TO BE IMPORTED GARDEN BLEND TOPSOIL TO AS 4419.
 3. MULCH- SUPPLY AND INSTALL 100MM DEEP MULCH AS SPECIFIED.
 4. SOIL-WETTING AGENT- SUPPLY SOIL-WETTING AGENT IN ACCORDANCE WITH MANUFACTURERS RECOMMENDATIONS.
 5. FERTILIZER- SLOW RELEASE FERTILIZER IN ACCORDANCE WITH MANUFACTURERS RECOMMENDATIONS N:P:K 11.3:1:5:6.1 AS REQUIRED
 6. CONTRACTOR RESPONSIBLE FOR ANY SETTLING OF SOIL TO TREE HOLES. TREE TO PLANTED TO ENSURE THAT THE TREE BASE IS FLUSH WITH THE TOP OF KERB AT THE END OF THE MAINTENANCE PERIOD.
 7. LOCATION SHOWN IS INDICATIVE ONLY. THE CONTRACTOR SHALL ACCURATELY LOCATE ALL SERVICES ON SITE PRIOR TO EXCAVATION OF TREE HOLES.

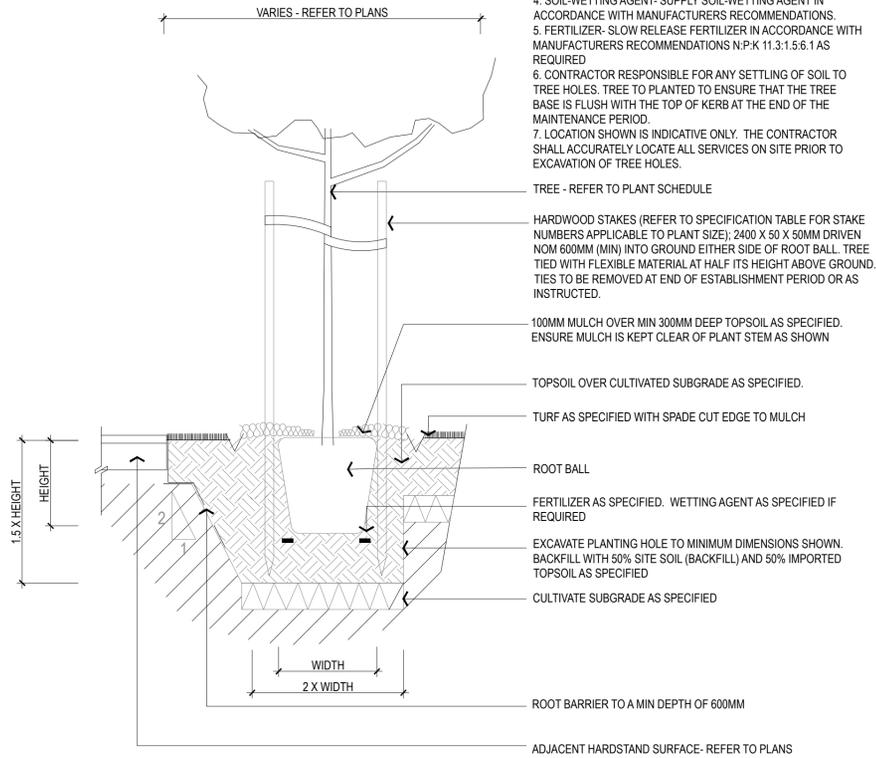


1 TYPICAL TREE PLANTING IN GRASS - SECTION
907 1:20 @ A1

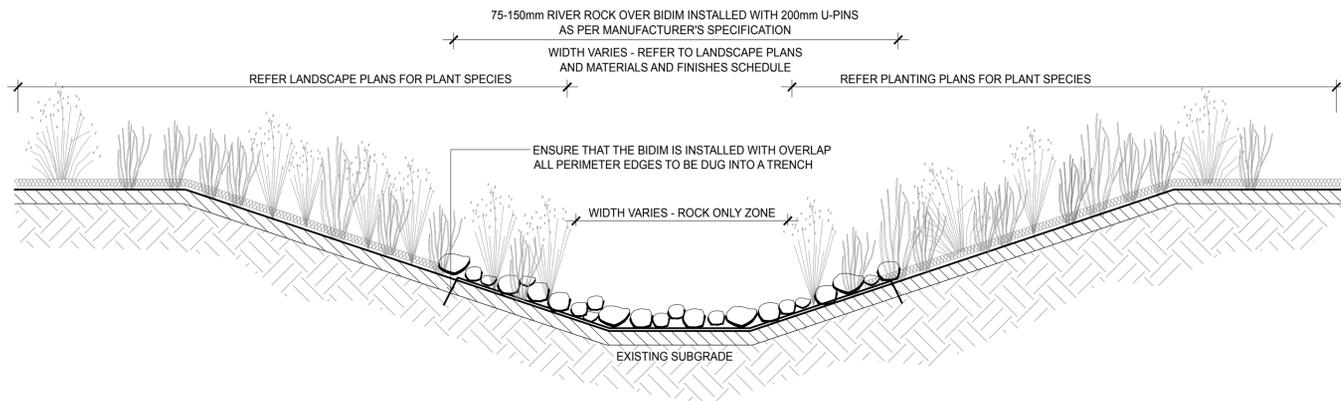



2 ROCK AND PLANTED SWALE - SECTION
907 1:50

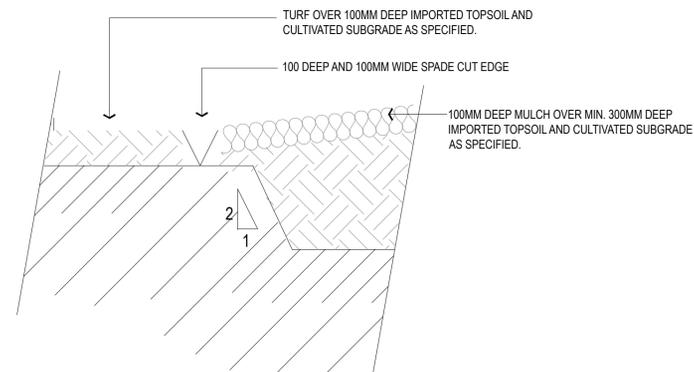


3 SPADE-CUT GARDEN EDGE - SECTION
907 1:10

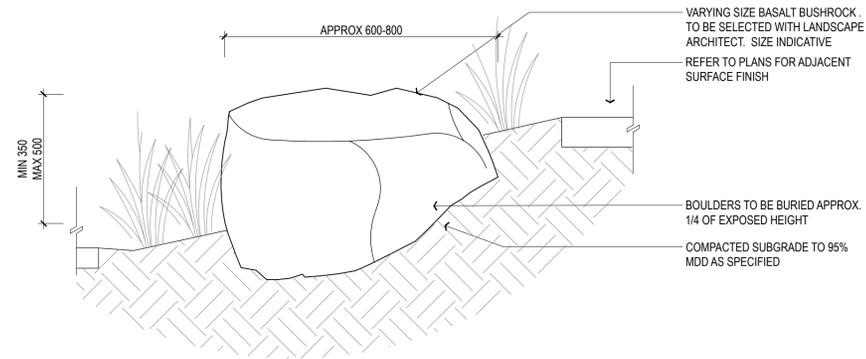

4 ROCK IN BATTER - SECTION
907 1:20

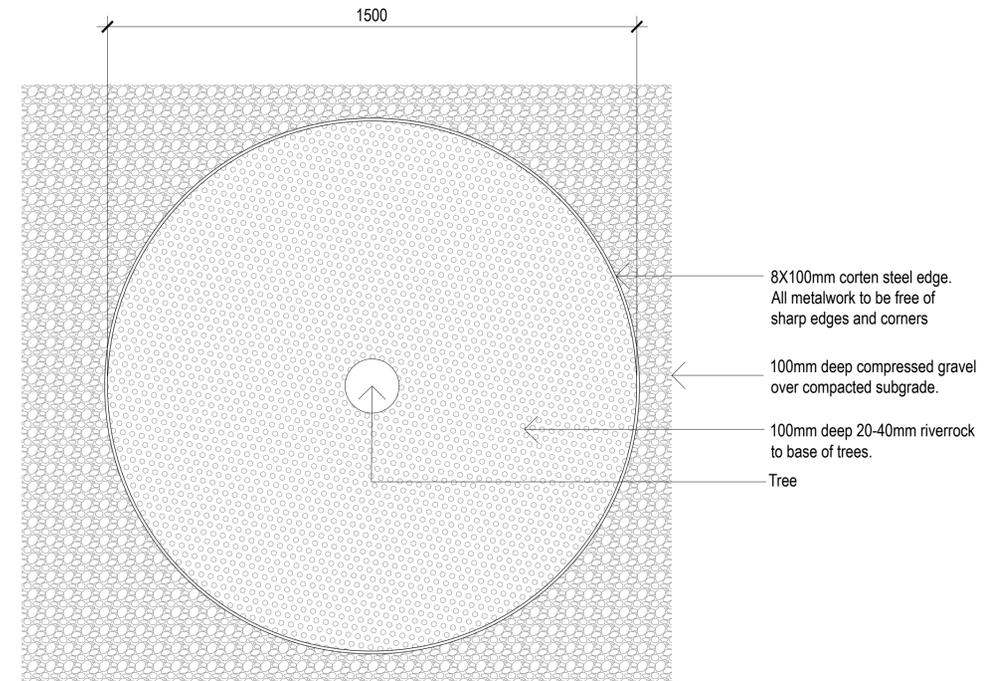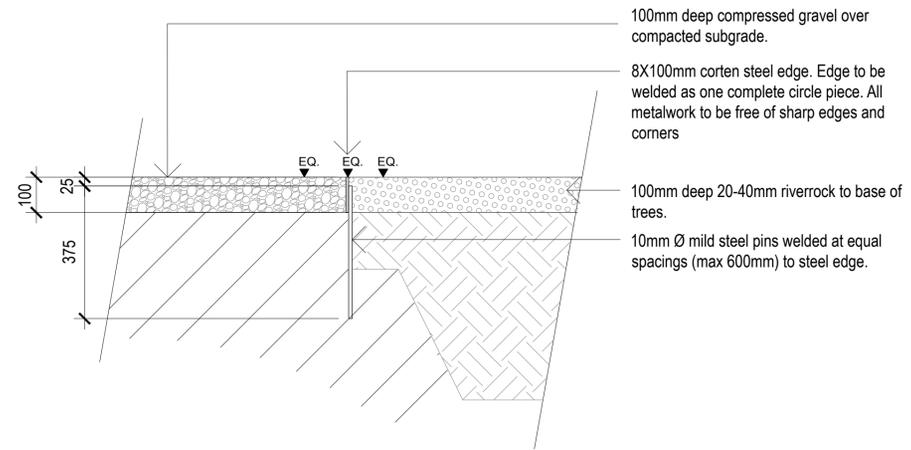

5 CUSTOM STEEL EDGE- for trees in compressed gravel
907 1:10 @ A1

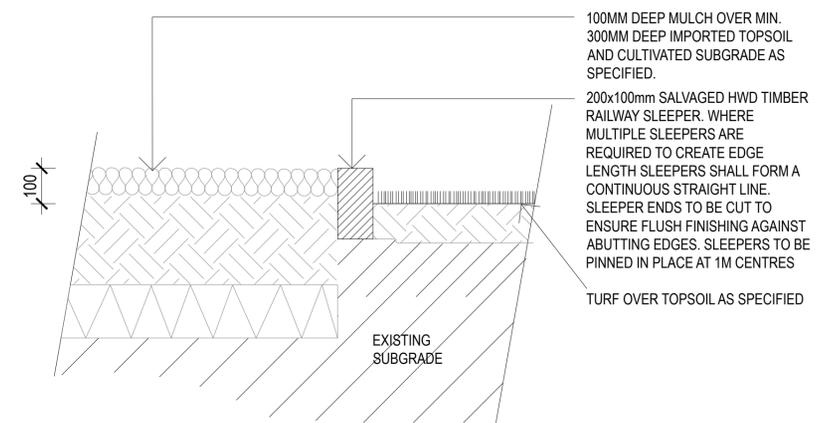

6 SLEEPER GARDEN EDGE
907 1:10 @ A1

Revision	Description	Date	Initial
C	FOR TENDER	31.07.20	
B	FINAL DRAFT FOR REVIEW	19.06.20	
A	PRELIMINARY- FOR INFORMATION ONLY	25.05.20	






PLUMMER & SMITH
landscape architecture / art / design
abn: 17 634 944 737 m 0437 599 011
po box 204 e dan@plummerandsmith.com.au
munwillumbah NSW 2484 w plummerandsmith.com.au
© Copyright

BYRON SHIRE COUNCIL


RAIL CORRIDOR PARK

CONSTRUCTION DETAILS

Designed DP	Drawn EC
Checked DP	Approved
Date 25.05.2020	Scale AS SHOWN
Job No. 211	Drawing No. 907
	Revision C

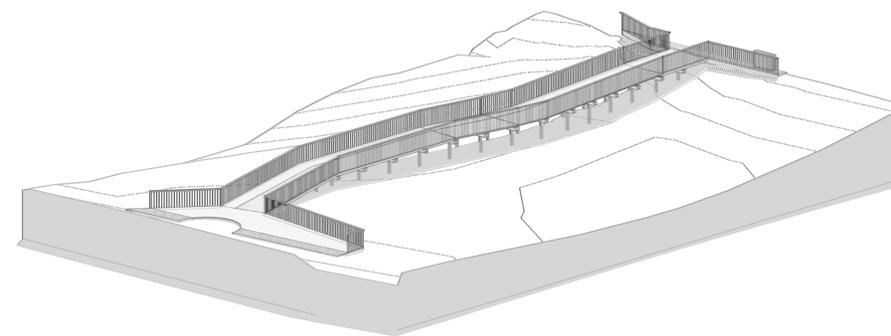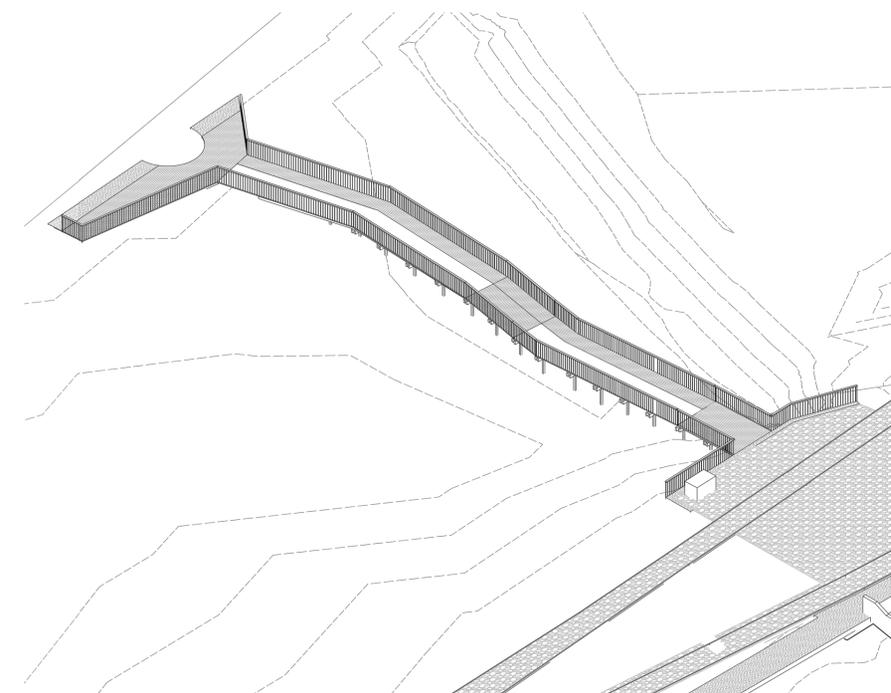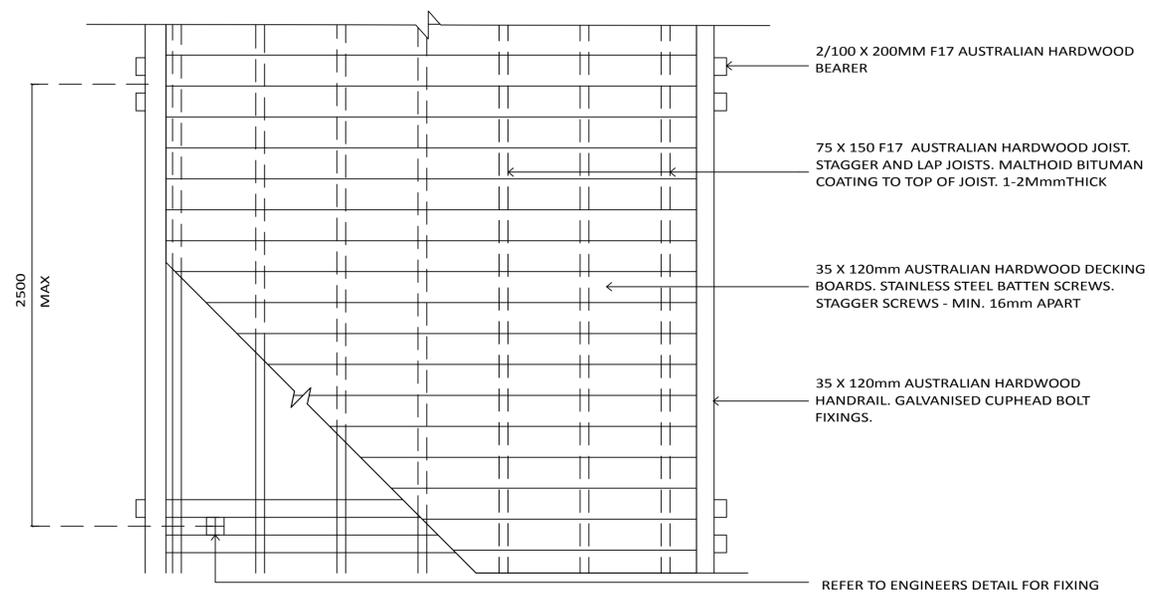

1 TYPICAL TIMBER BOARDWALK - PLAN
908 1:20 @ A1

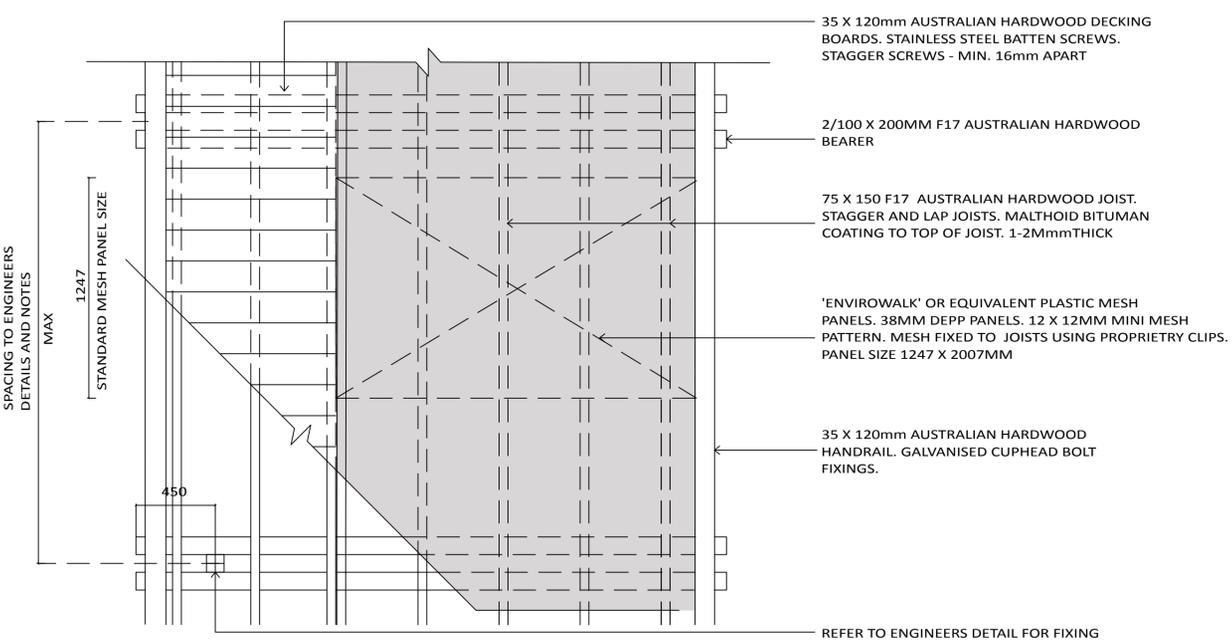

3 BOARDWALK 3D VIEWS
908 NS

2 TYPICAL TIMBER & MESH - PLAN
908 1:20 @ A1

Revision	Description	Date	Initial
C	FOR TENDER	31.07.20	
B	FINAL DRAFT FOR REVIEW	19.06.20	
A	PRELIMINARY- FOR INFORMATION ONLY	25.05.20	



AS SHOWN @ A1


PLUMMER & SMITH
landscape architecture / art / design
abn: 17 634 944 737 m 0437 599 011
po box 204 e dan@plummerandsmith.com.au
munwillumbah NSW 2484 w plummerandsmith.com.au
© Copyright

BYRON SHIRE COUNCIL


RAIL CORRIDOR PARK

CONSTRUCTION DETAILS





Designed	DP	Drawn	EC
Checked	DP	Approved	
Date	25.05.2020	Scale	AS SHOWN
Job No.	211	Drawing No.	908
		Revision	C

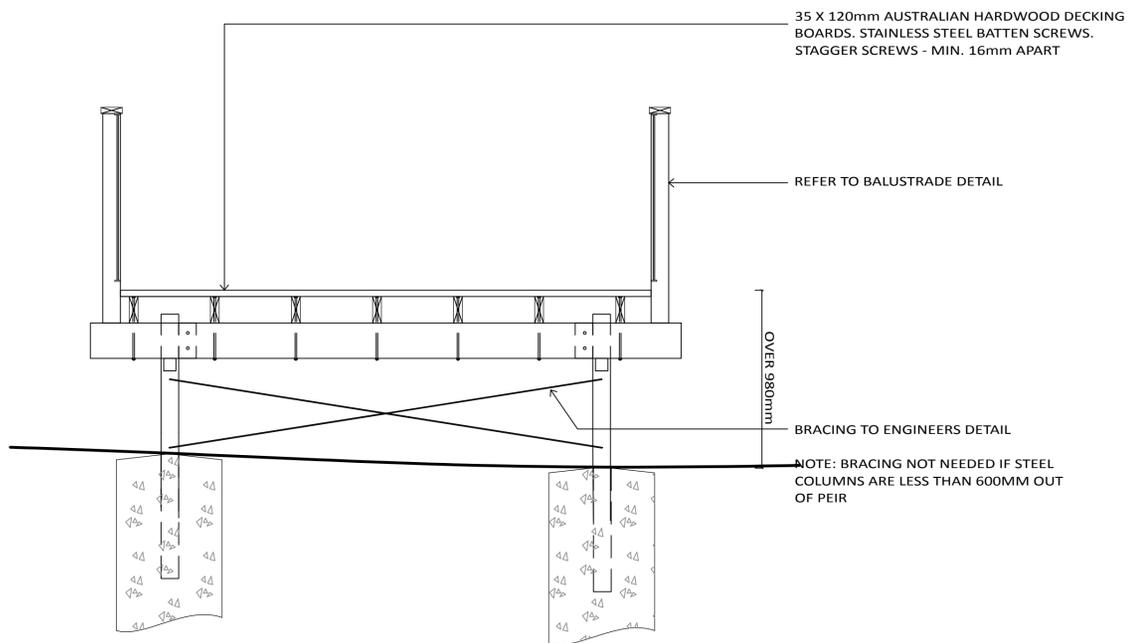


1 TIMBER BOARDWALK WITH BALUSTRADE - SECTION
909 1:20 @ A1

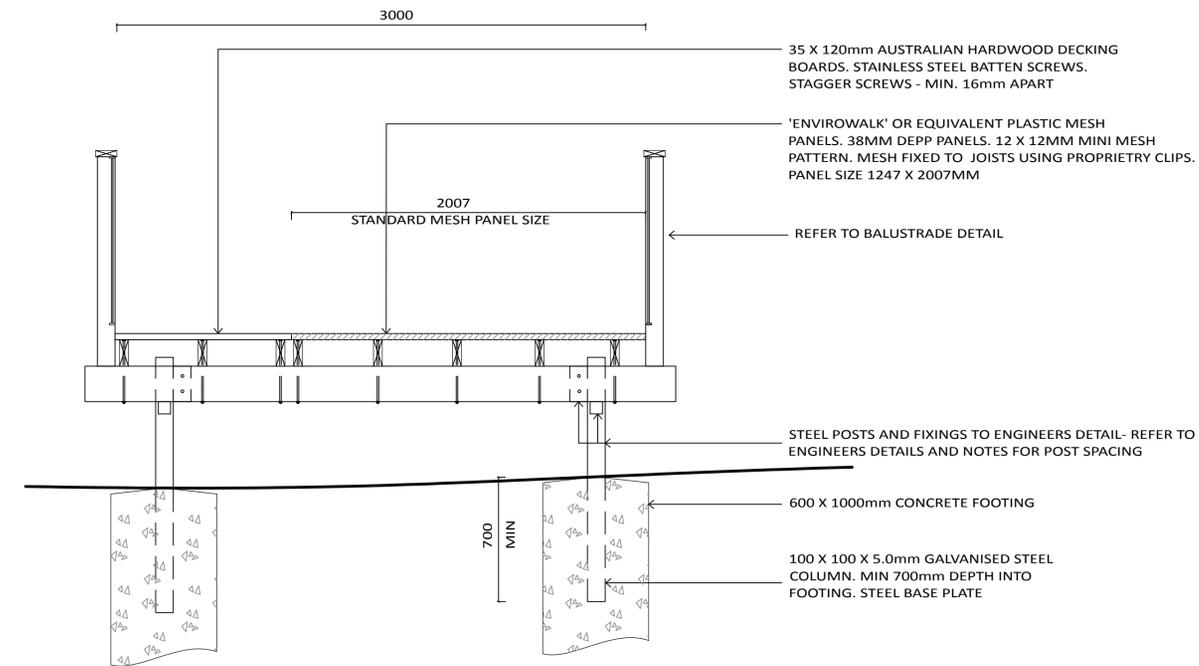

2 TIMBER AND MESH BOARDWALK WITH BALUSTRADE - SECTION
909 1:20 @ A1

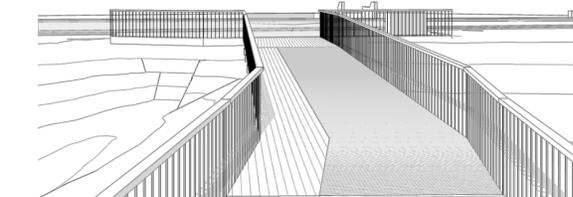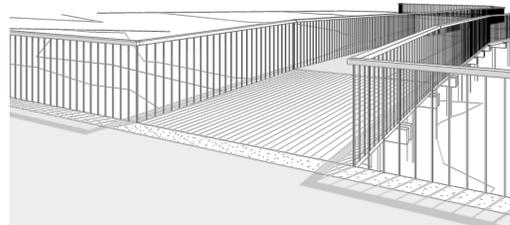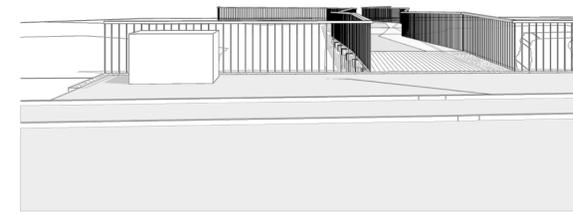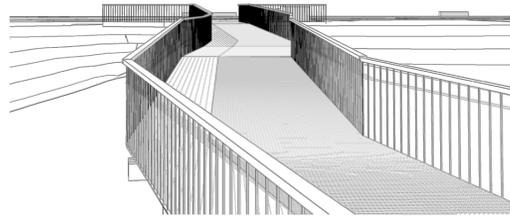

3 BOARDWALK 3D VIEWS
909 NA

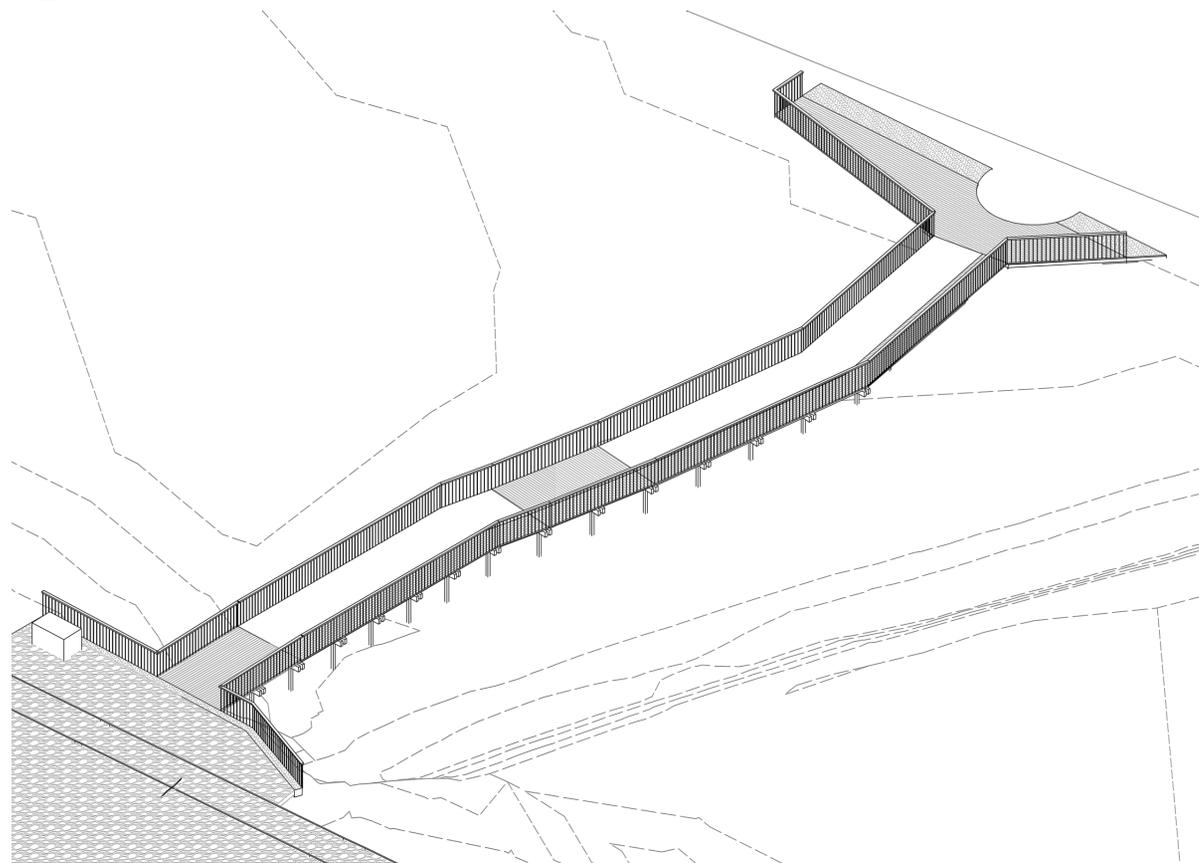

4 BOARDWALK 3D VIEWS
909 NA

Revision	Description	Date	Initial
C	FOR TENDER	31.07.20	
B	FINAL DRAFT FOR REVIEW	19.06.20	
A	PRELIMINARY- FOR INFORMATION ONLY	25.05.20	

AS SHOWN @ A1


PLUMMER & SMITH
landscape architecture / art / design
abn: 17 634 944 737 m 0437 599 011
po box 204 e dan@plummerandsmith.com.au
munwillumbah NSW 2484 w plummerandsmith.com.au
© Copyright

BYRON SHIRE COUNCIL


RAIL CORRIDOR PARK

CONSTRUCTION DETAILS

Designed DP	Drawn EC
Checked DP	Approved
Date 25.05.2020	Scale AS SHOWN
Job No. 211	Drawing No. 909 Revision C

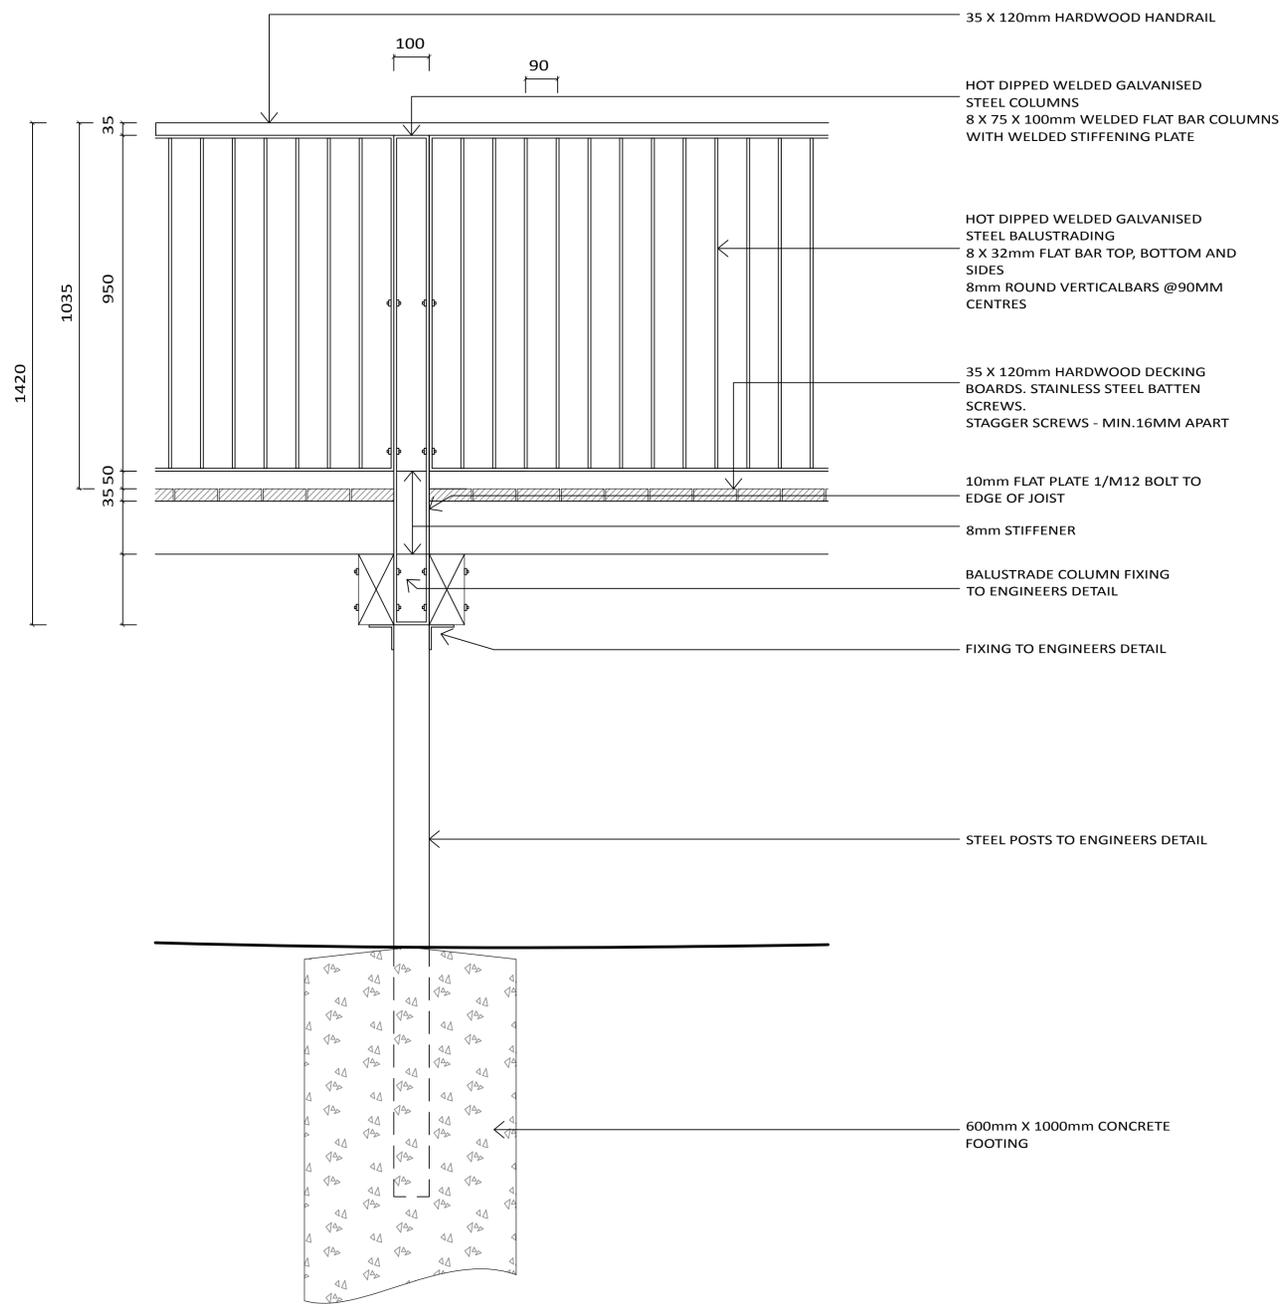

1 TYPICAL BALUSTRADE- ELEVATION
910 1:10 @ A1

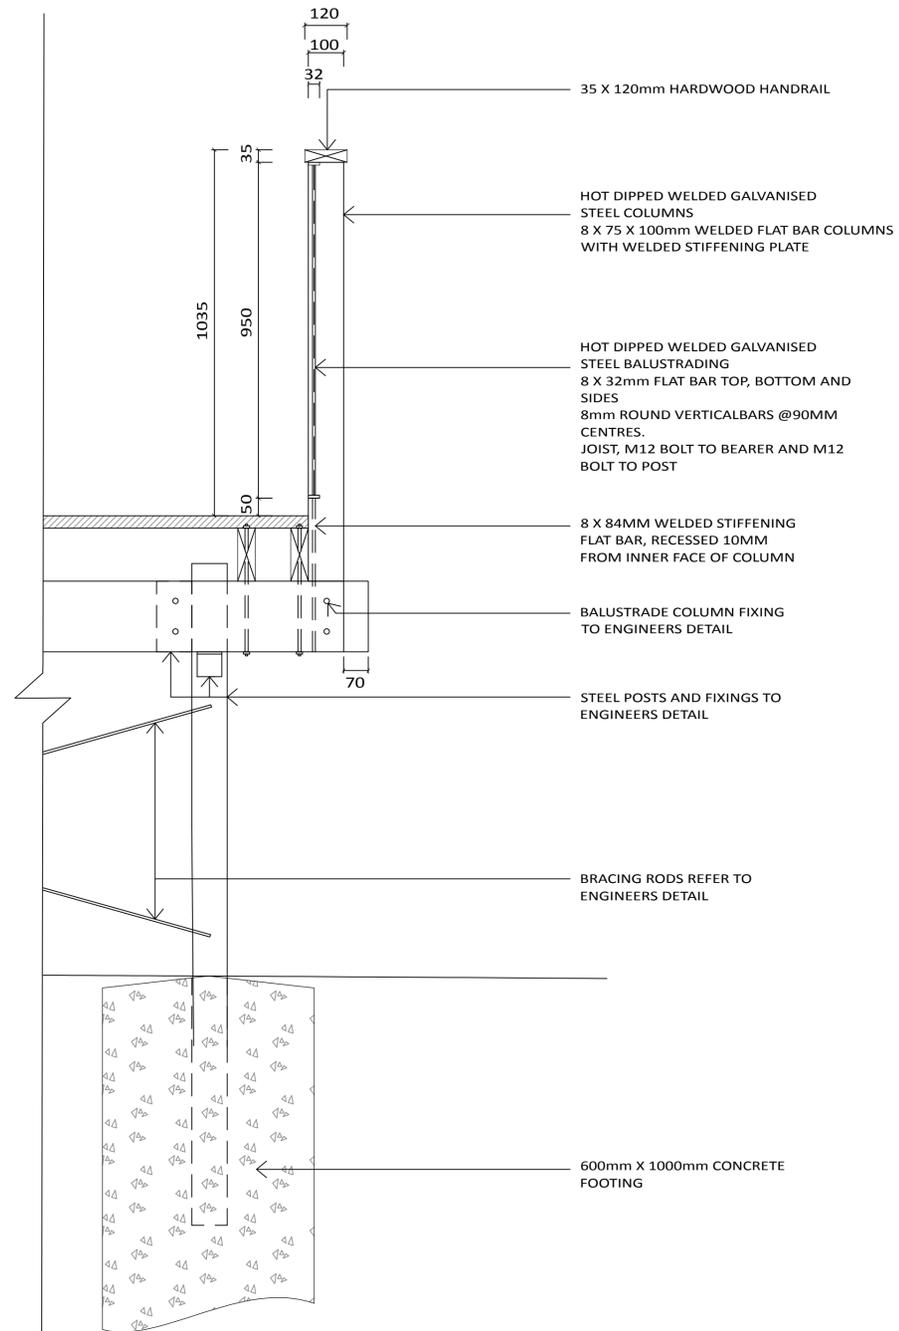

2 TYPICAL BALUSTRADE- SECTION
910 1:10 @ A1

Revision	Description	Date	Initial
C	FOR TENDER	31.07.20	
B	FINAL DRAFT FOR REVIEW	19.06.20	
A	PRELIMINARY- FOR INFORMATION ONLY	25.05.20	

AS SHOWN @ A1


PLUMMER & SMITH
landscape architecture / art / design
abn: 17 634 944 737 m 0437 599 011
po box 204 e dan@plummerandsmith.com.au
munwillumbah NSW 2484 w plummerandsmith.com.au
© Copyright

BYRON SHIRE COUNCIL

RAIL CORRIDOR PARK

CONSTRUCTION DETAILS

Designed	DP	Drawn	EC
Checked	DP	Approved	
Date	25.05.2020	Scale	AS SHOWN
Job No.	211	Drawing No.	910
		Revision	C

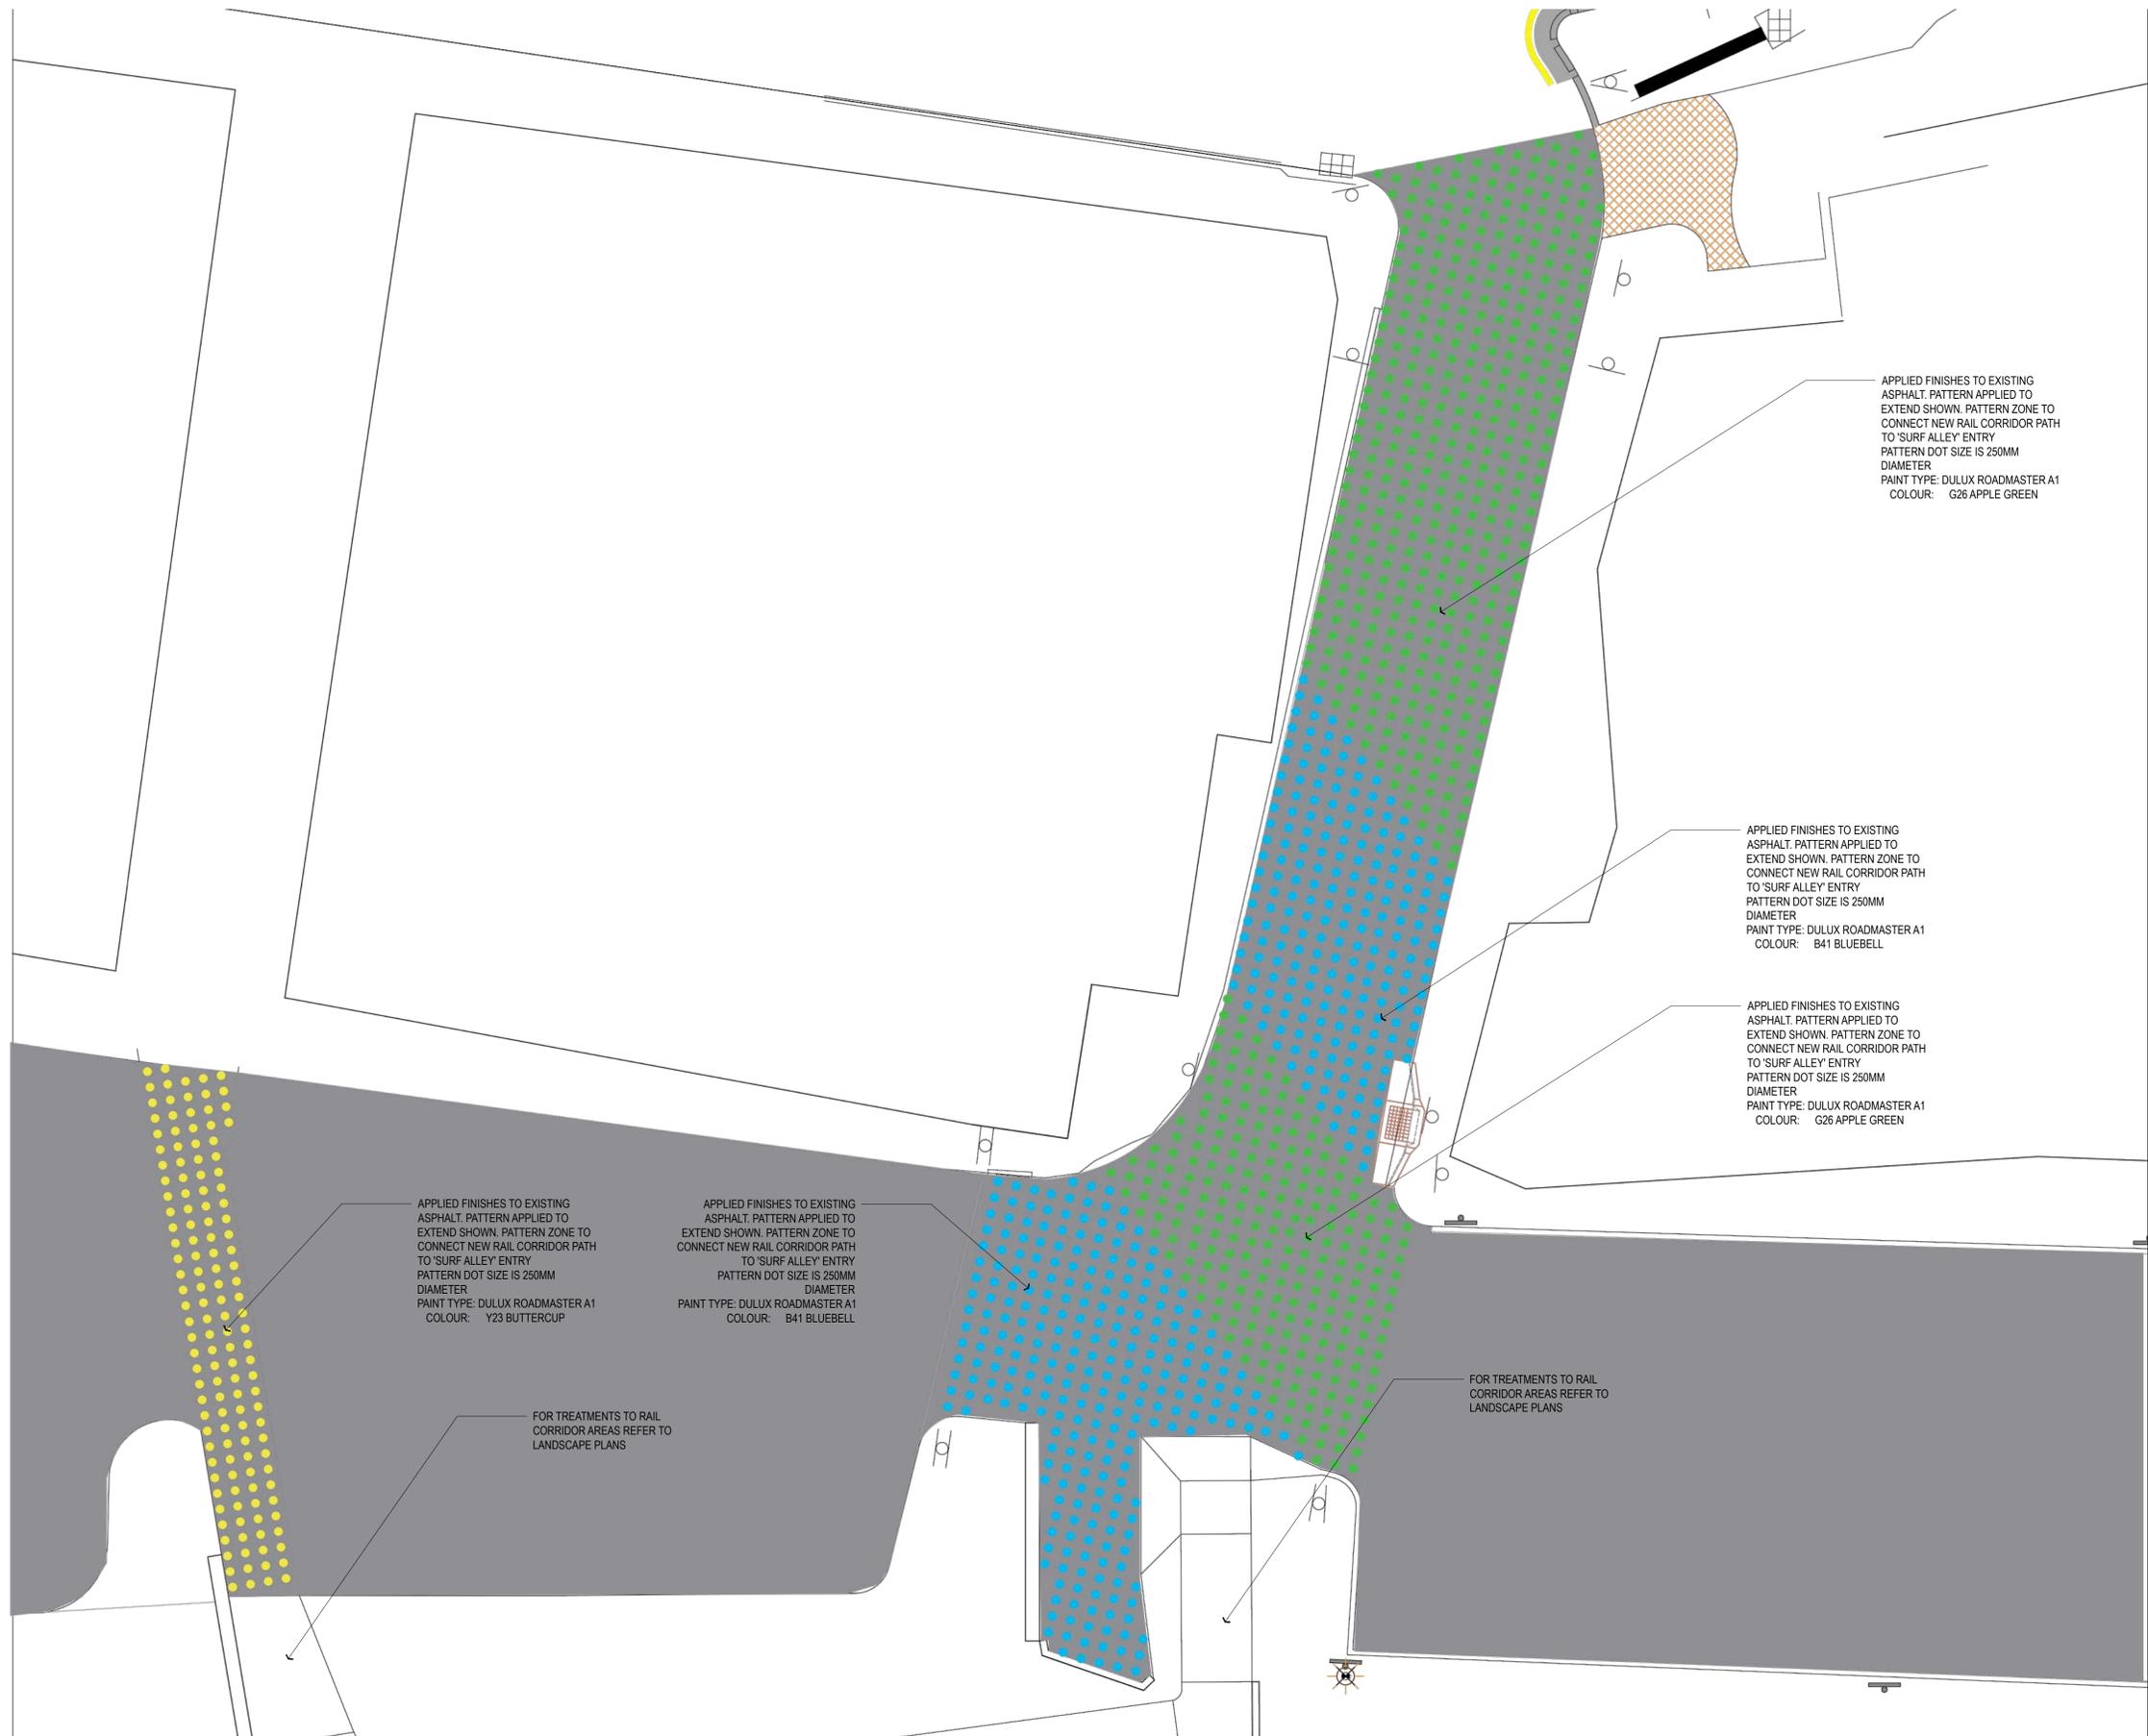

Revision	Description	Date	Initial
B	FOR TENDER	31.07.20	
A	FINAL DRAFT FOR REVIEW	19.06.20	

AS SHOWN @ A1


PLUMMER & SMITH
 landscape architecture / art / design
 abn: 17 634 944 737 m 0437 599 011
 po box 204 e dan@plummerandsmith.com.au
 munwillingbah NSW 2484 w plummerandsmith.com.au
 © Copyright

BYRON SHIRE COUNCIL
RAIL CORRIDOR PARK

CONSTRUCTION DETAILS


Designed	DP	Drawn	EC
Checked	DP	Approved	
Date	19.06.2020	Scale	AS SHOWN
Job No.	211	Drawing No.	911
		Revision	B

1 FEATURE APPLIED FINISHES TO BYRON LANE AND 'SURF ALLEY' CONNECTION- PLAN
 911 1:100 @ A1

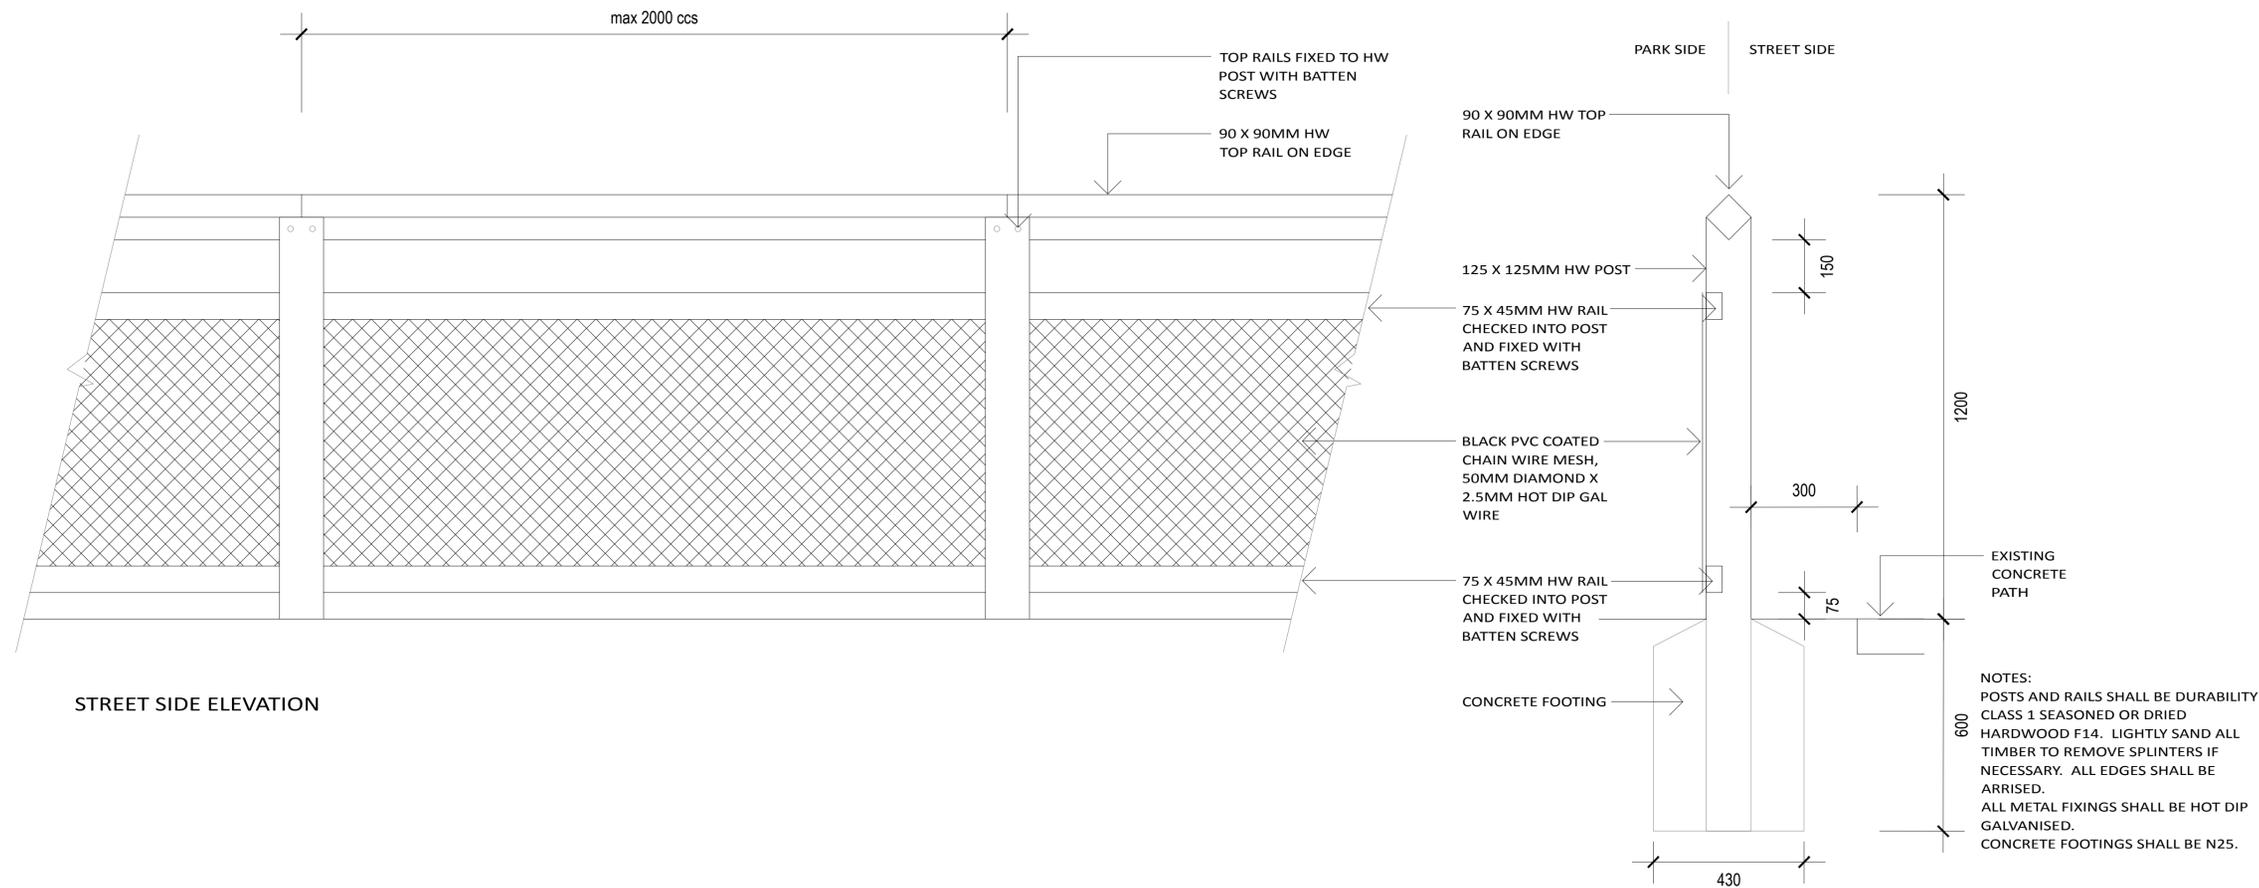

STREET SIDE ELEVATION

1 TIMBER FENCE
912 1:10 @ A1

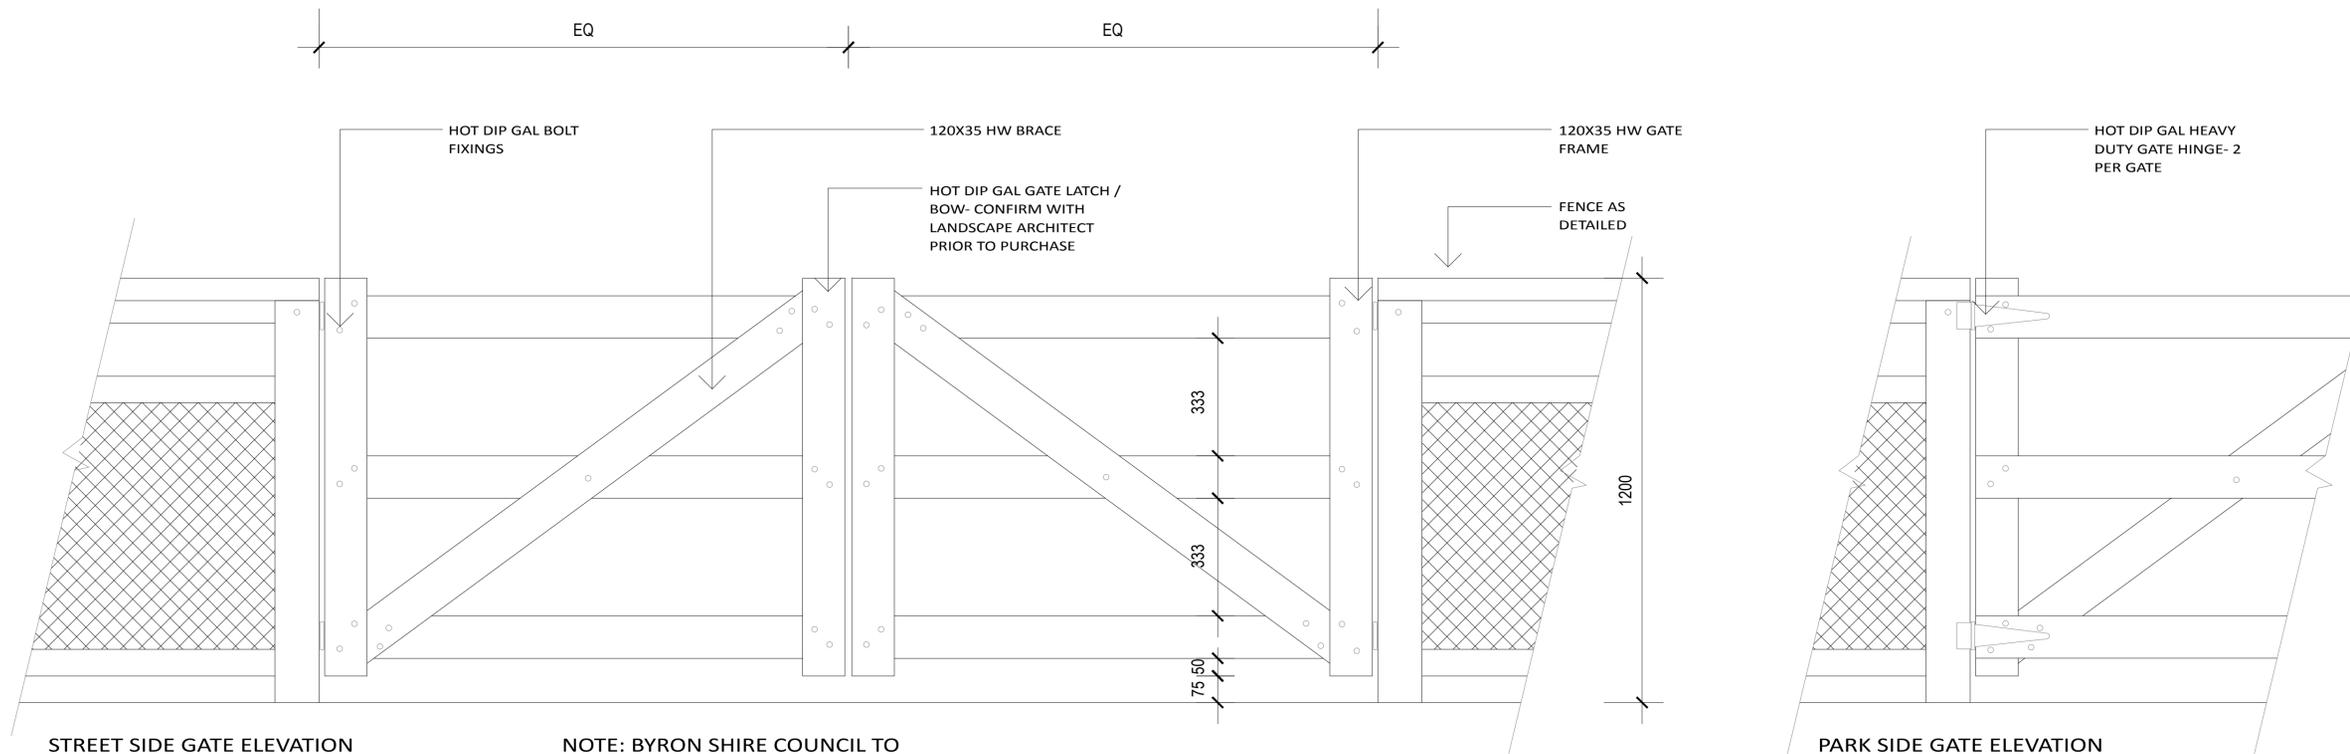

2 TIMBER FENCE GATES (FRONT)
912 1:10 @ A1

3 TIMBER FENCE GATES (BACK)
912 1:10 @ A1

Revision	Description	Date	Initial
A	FOR TENDER	31.07.20	

AS SHOWN @ A1

PLUMMER & SMITH
 landscape architecture / art / design
 abn: 17 634 944 737 m 0437 599 011
 po box 204 e dan@plummerandsmith.com.au
 munwillimbah NSW 2484 w plummerandsmith.com.au
 © Copyright

BYRON SHIRE COUNCIL
 RAIL CORRIDOR PARK

CONSTRUCTION DETAILS

Designed DP	Drawn DP
Checked DP	Approved
Date 31.07.2020	Scale AS SHOWN
Job No. 211	Revision A